
NOVI FUNERAL HOME

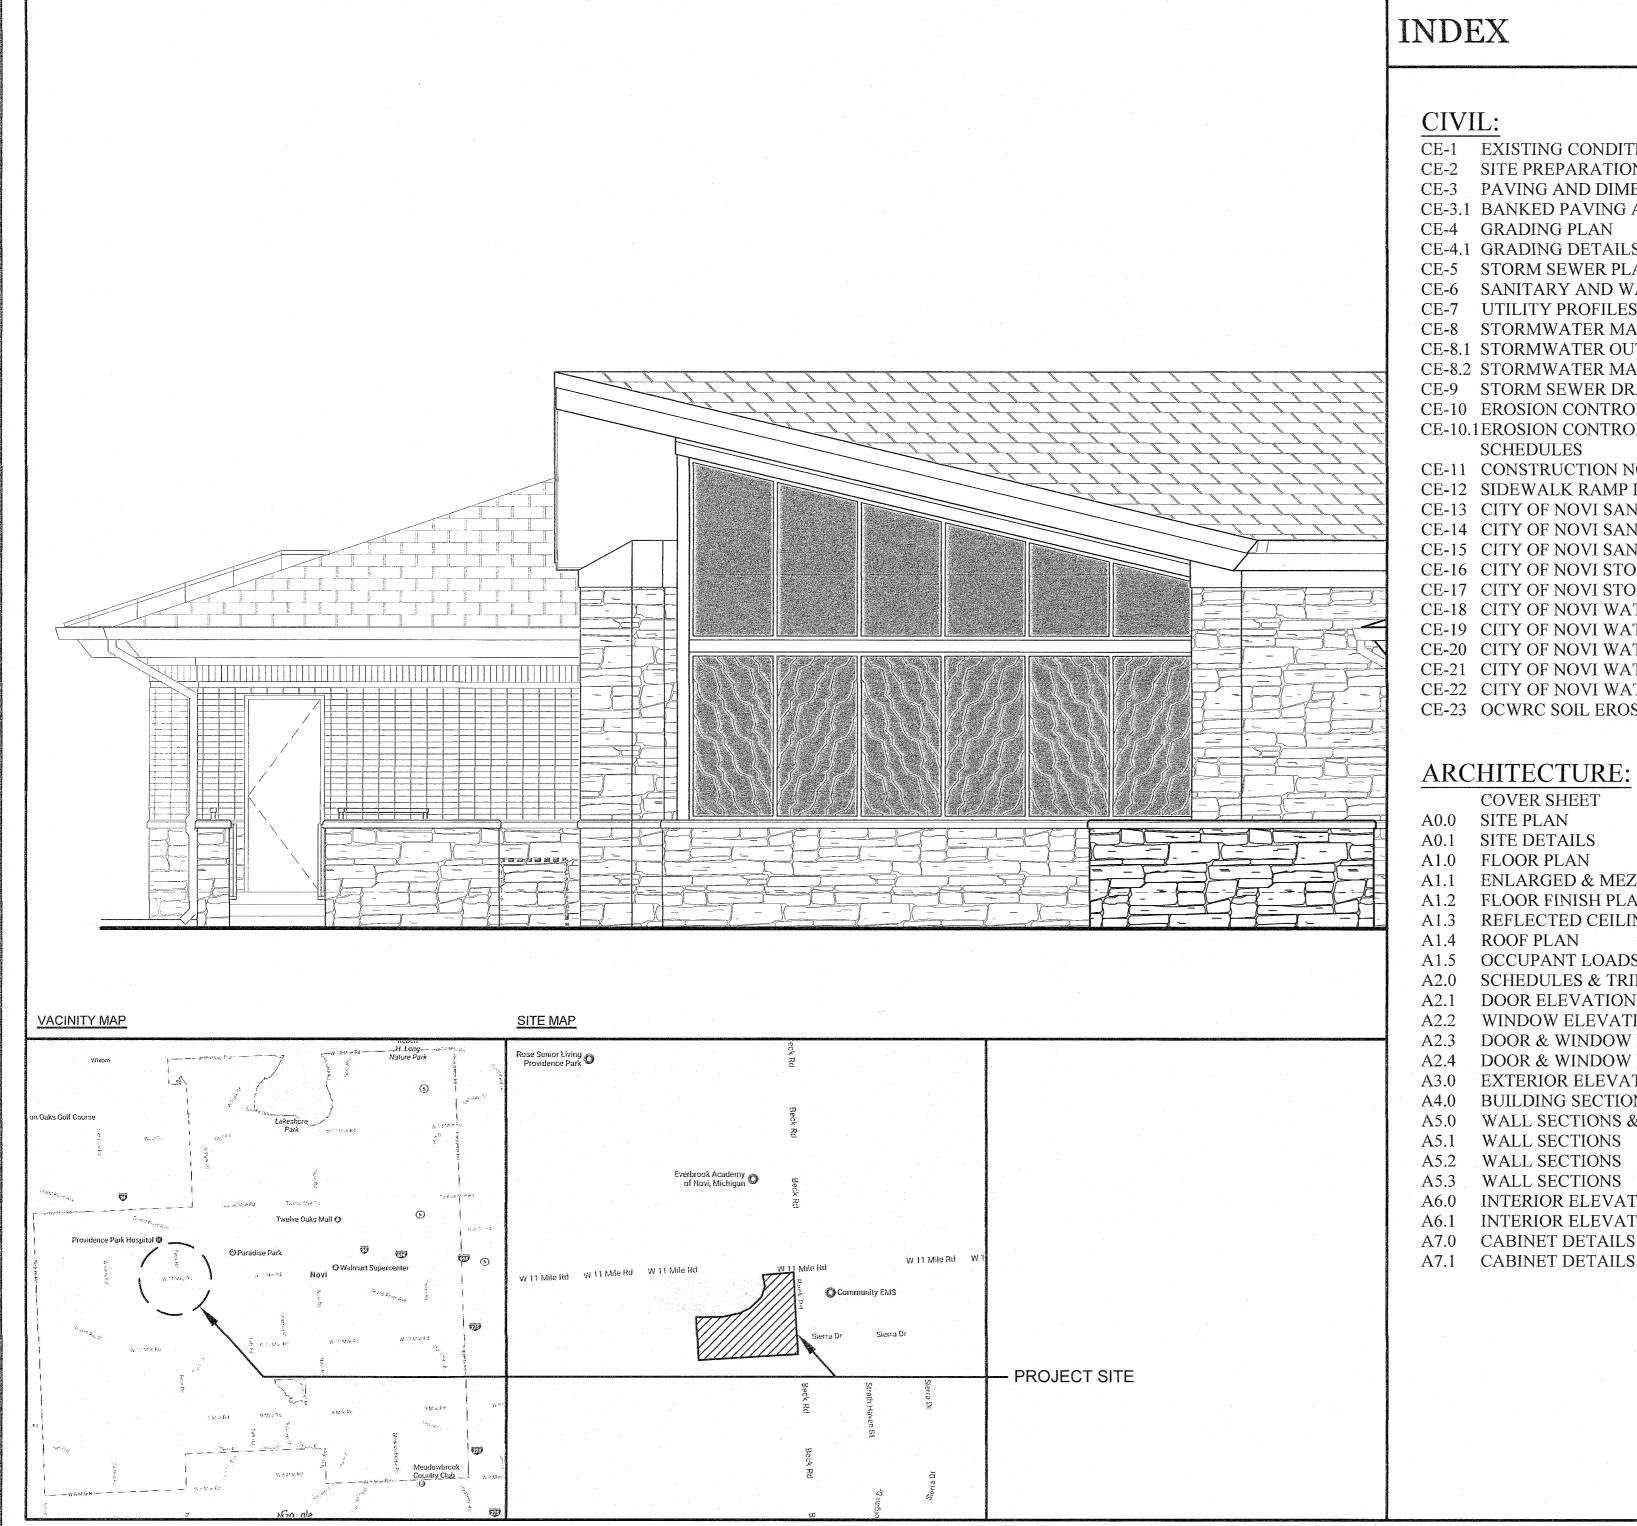

INDEX

CIVIL:

CE-1 EXISTING CONDITIONS

CE-2 SITE PREPARATION PLAN

CE-3 PAVING AND DIMENSION PLAN

CE-3.1 BANKED PAVING AND DIMENSION PLAN CE-4 GRADING PLAN

CE-4.1 GRADING DETAILS

CE-5 STORM SEWER PLAN CE-6 SANITARY AND WATERMAIN PLAN

CE-7 UTILITY PROFILES

CE-8 STORMWATER MANAGEMENT PLAN CE-8.1 STORMWATER OUTLET PLAN

CE-8.2 STORMWATER MANAGEMENT DETAILS CE-9 STORM SEWER DRAINAGE AREAS

CE-10 EROSION CONTROL PLAN CE-10.1EROSION CONTROL MAINTENANCE

SCHEDULES

CE-11 CONSTRUCTION NOTES AND DETAILS CE-12 SIDEWALK RAMP DETAILS

CE-13 CITY OF NOVI SANITARY SEWER DETAILS CE-14 CITY OF NOVI SANITARY SEWER DETAILS CE-15 CITY OF NOVI SANITARY SEWER DETAILS

CE-16 CITY OF NOVI STORM SEWER DETAILS CE-17 CITY OF NOVI STORM SEWER DETAILS CE-18 CITY OF NOVI WATERMAIN DETAILS

CE-19 CITY OF NOVI WATERMAIN DETAILS CE-20 CITY OF NOVI WATERMAIN DETAILS

CE-21 CITY OF NOVI WATERMAIN DETAILS CE-22 CITY OF NOVI WATERMAIN DETAILS

CE-23 OCWRC SOIL EROSION DETAILS

ARCHITECTURE:

COVER SHEET A0.0 SITE PLAN

A0.1 SITE DETAILS

A1.0 FLOOR PLAN A1.1 ENLARGED & MEZZANINE PLANS

A1.2 FLOOR FINISH PLAN A1.3 REFLECTED CEILING PLAN

A1.4 ROOF PLAN

A1.5 OCCUPANT LOADS & EGRESS PLAN A2.0 SCHEDULES & TRIM PROFILES

A2.1 DOOR ELEVATIONS & DETAILS

A2.2 WINDOW ELEVATIONS & DETAILS

A2.3 DOOR & WINDOW DETAILS A2.4 DOOR & WINDOW DETAILS

A3.0 EXTERIOR ELEVATIONS

A4.0 BUILDING SECTIONS

A5.0 WALL SECTIONS & PLAN DETAILS

A5.1 WALL SECTIONS A5.2 WALL SECTIONS

A5.3 WALL SECTIONS

A6.0 INTERIOR ELEVATIONS

A6.1 INTERIOR ELEVATIONS

A7.0 CABINET DETAILS

STRUCTURAL: FOUNDATION PLAN

WALL & MEZZANINE FRAMING PLAN S3.1 ROOF FRAMING PLAN

SPECIAL INSPECTION SCHEDULES

GENERAL NOTES

LEGENDS & SCHEDULES

TYPICAL SLAB ON GRADE DETAILS

TYPICAL DETAILS

TYPICAL DETAILS TYPICAL DETAILS

S4.8 SECTIONS & DETAILS

S4.9 SECTIONS & DETAILS S5.1 SHEAR WALL DETAILS

MECHANICAL:

M0.1 NOTES & LEGEND

M0.2 SCHEDULES M0.3 HVAC DETAILS

M2.0 HVAC PLAN

ELECTRICAL:

E0.1 NOTES & LEGEND E0.2 SCHEDULES

E1.0 SITE PLAN - ELECTRICAL

E1.1 SITE PLAN - LIGHTING PHOTOMETRICS LUMINAIRE SPECS

LUMINAIRE SPECS E1.4 LUMINAIRE SPECS

ELECTRICAL PLAN

MEZZANINE ELECTRICAL PLAN

LIGHTING PLAN

PLUMBING:

NOTES & LEGENDS

DETAILS P0.3 RISER DIAGRAMS

PLUMBING PLAN

PLUMBING PLAN - UNDERFLOOR PLUMBING PLAN - WATER & VENT

PLUMBING PLAN - NATURAL GAS

PLUMBING PLAN - ROOF & MEZZANINE

PROJECT CODE REQUIREMENTS

- 2015 MICHIGAN BUILDING CODE **BUILDING CODE**

ELECTRICAL CODE - 2014 STATE OF MICHIGAN ELECTRIC CODE PLUMBING CODE - 2015 MICHIGAN PLUMBING CODE

- 2015 MICHIGAN MECHANICAL CODE

ENERGY CODE - 2015 ENERGY CODE

- 2012 IFC

FIRE CODE ACCESSIBILITY CODE - ICC/ANSI A117.1. 2009 MICHIGAN BARRIOR

FREE DESIGN LAW * APPLICABLE CITY AMENDMENTS

PROJECT NOTES:

MECHANICAL CODE

- THIS PROJECT WHEN COMPLETED WILL PROVIDE AN ACCESSIBLE ROUTE OF TRAVEL TO ALL PORTIONS OF THE BUILDING, BUILDING ENTRANCES.
- PROJECT SHALL BE EQUIPPED WITH A FIRE ALARM SYSTEM IN ACCORDANCE WITH LOCAL CODE. ALARM SYSTEM SHALL BE A DEFERRED SUBMITTAL TO THE APPLICABLE CITY/COUNTY OFFICES FOR REVIEW AND APPROVAL PRIOR TO INSTALLATION.
- AND INSTALLED IN ACCORDANCE WITH LOCAL CODE. THE FIRE SPRINKLER SYSTEM WILL BE A DEFERRED SUBMITTAL TO THE APPLICABLE CITY/COUNTY OFFICES FOR REVIEW AND APPROVAL PRIOR TO INSTALLATION.

DEFERRED SUBMITTALS:

I. FIRE SPRINKLER SYSTEM & FIRE ALARM 2. ENGINEERED TRUSS SYSTEMS

PROJECT DATA AND CALCULATIONS

A3, ADDITIONAL OCCUPANCIES

USE AND OCCUPANCY CLASSIFICATION

CONSTRUCTION TYPE: V-B FIRE SPRINKLER YES NUMBER OF STORIES 1 STORY

ALLOWABLE BUILDING AREA CALCULATIONS:

INITIAL ALLOWABLE AREA: AREA INCREASE PER FLOOR

S.F. SPRINKLER SYSTEM TOTAL ALLOWABLE AREA PER FLOOR

ACTUAL BUILDING AREA: CONDITIONED AREA:

FIRST FLOOR 10,356 S.F. NON-CONDITIONED AREA: PORCHES, CAR PORT & GARAGE GROSS SQUARE FOOTAGE:

PROJECT STATISTICS:

ZONING NEW CONSTRUCTION - USE PERMIT

PARKING SPACES REQUIRED: SPACES PROVIDED: SPACES BANKED: ACCESSIBLE SPACES REQUIRED: ACCESSIBLE SPACES PROVIDED:

PROPERTY LOCATION:

NOVI, MICHINGAN 48374

25805 BECK RD.

CIVIL ENGINEER ZEIMET WOZNIAK CIVIL ENGINEERS 55800 GRAND RIVER AVE, SUITE 100

NEW HUDSON, MI 48165

248-437-5099


M.E.P. ENGINEER JORDAN & SKALA **ENGINEERING**

17855 N. DALLAS PARKWAY, STE. 320 DALLAS, TX 75287 469-385-1616

STRUCTURAL ENGINEER RODNEY McCOMAS, PE 1717 EAST 116th STREET, SUITE 200

CARMEL, INDIANA 46032 317-850-0402

ARCHITECT JST ARCHITECTS 2919 WELBORN STREET SUITE 101 DALLAS, TX. 75219 214-522-4033

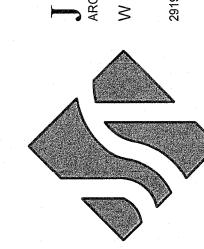


SSUE DATE:

OCTOBER 6, 2017 PERMIT REVIEW

SHEET NO.

A0.0

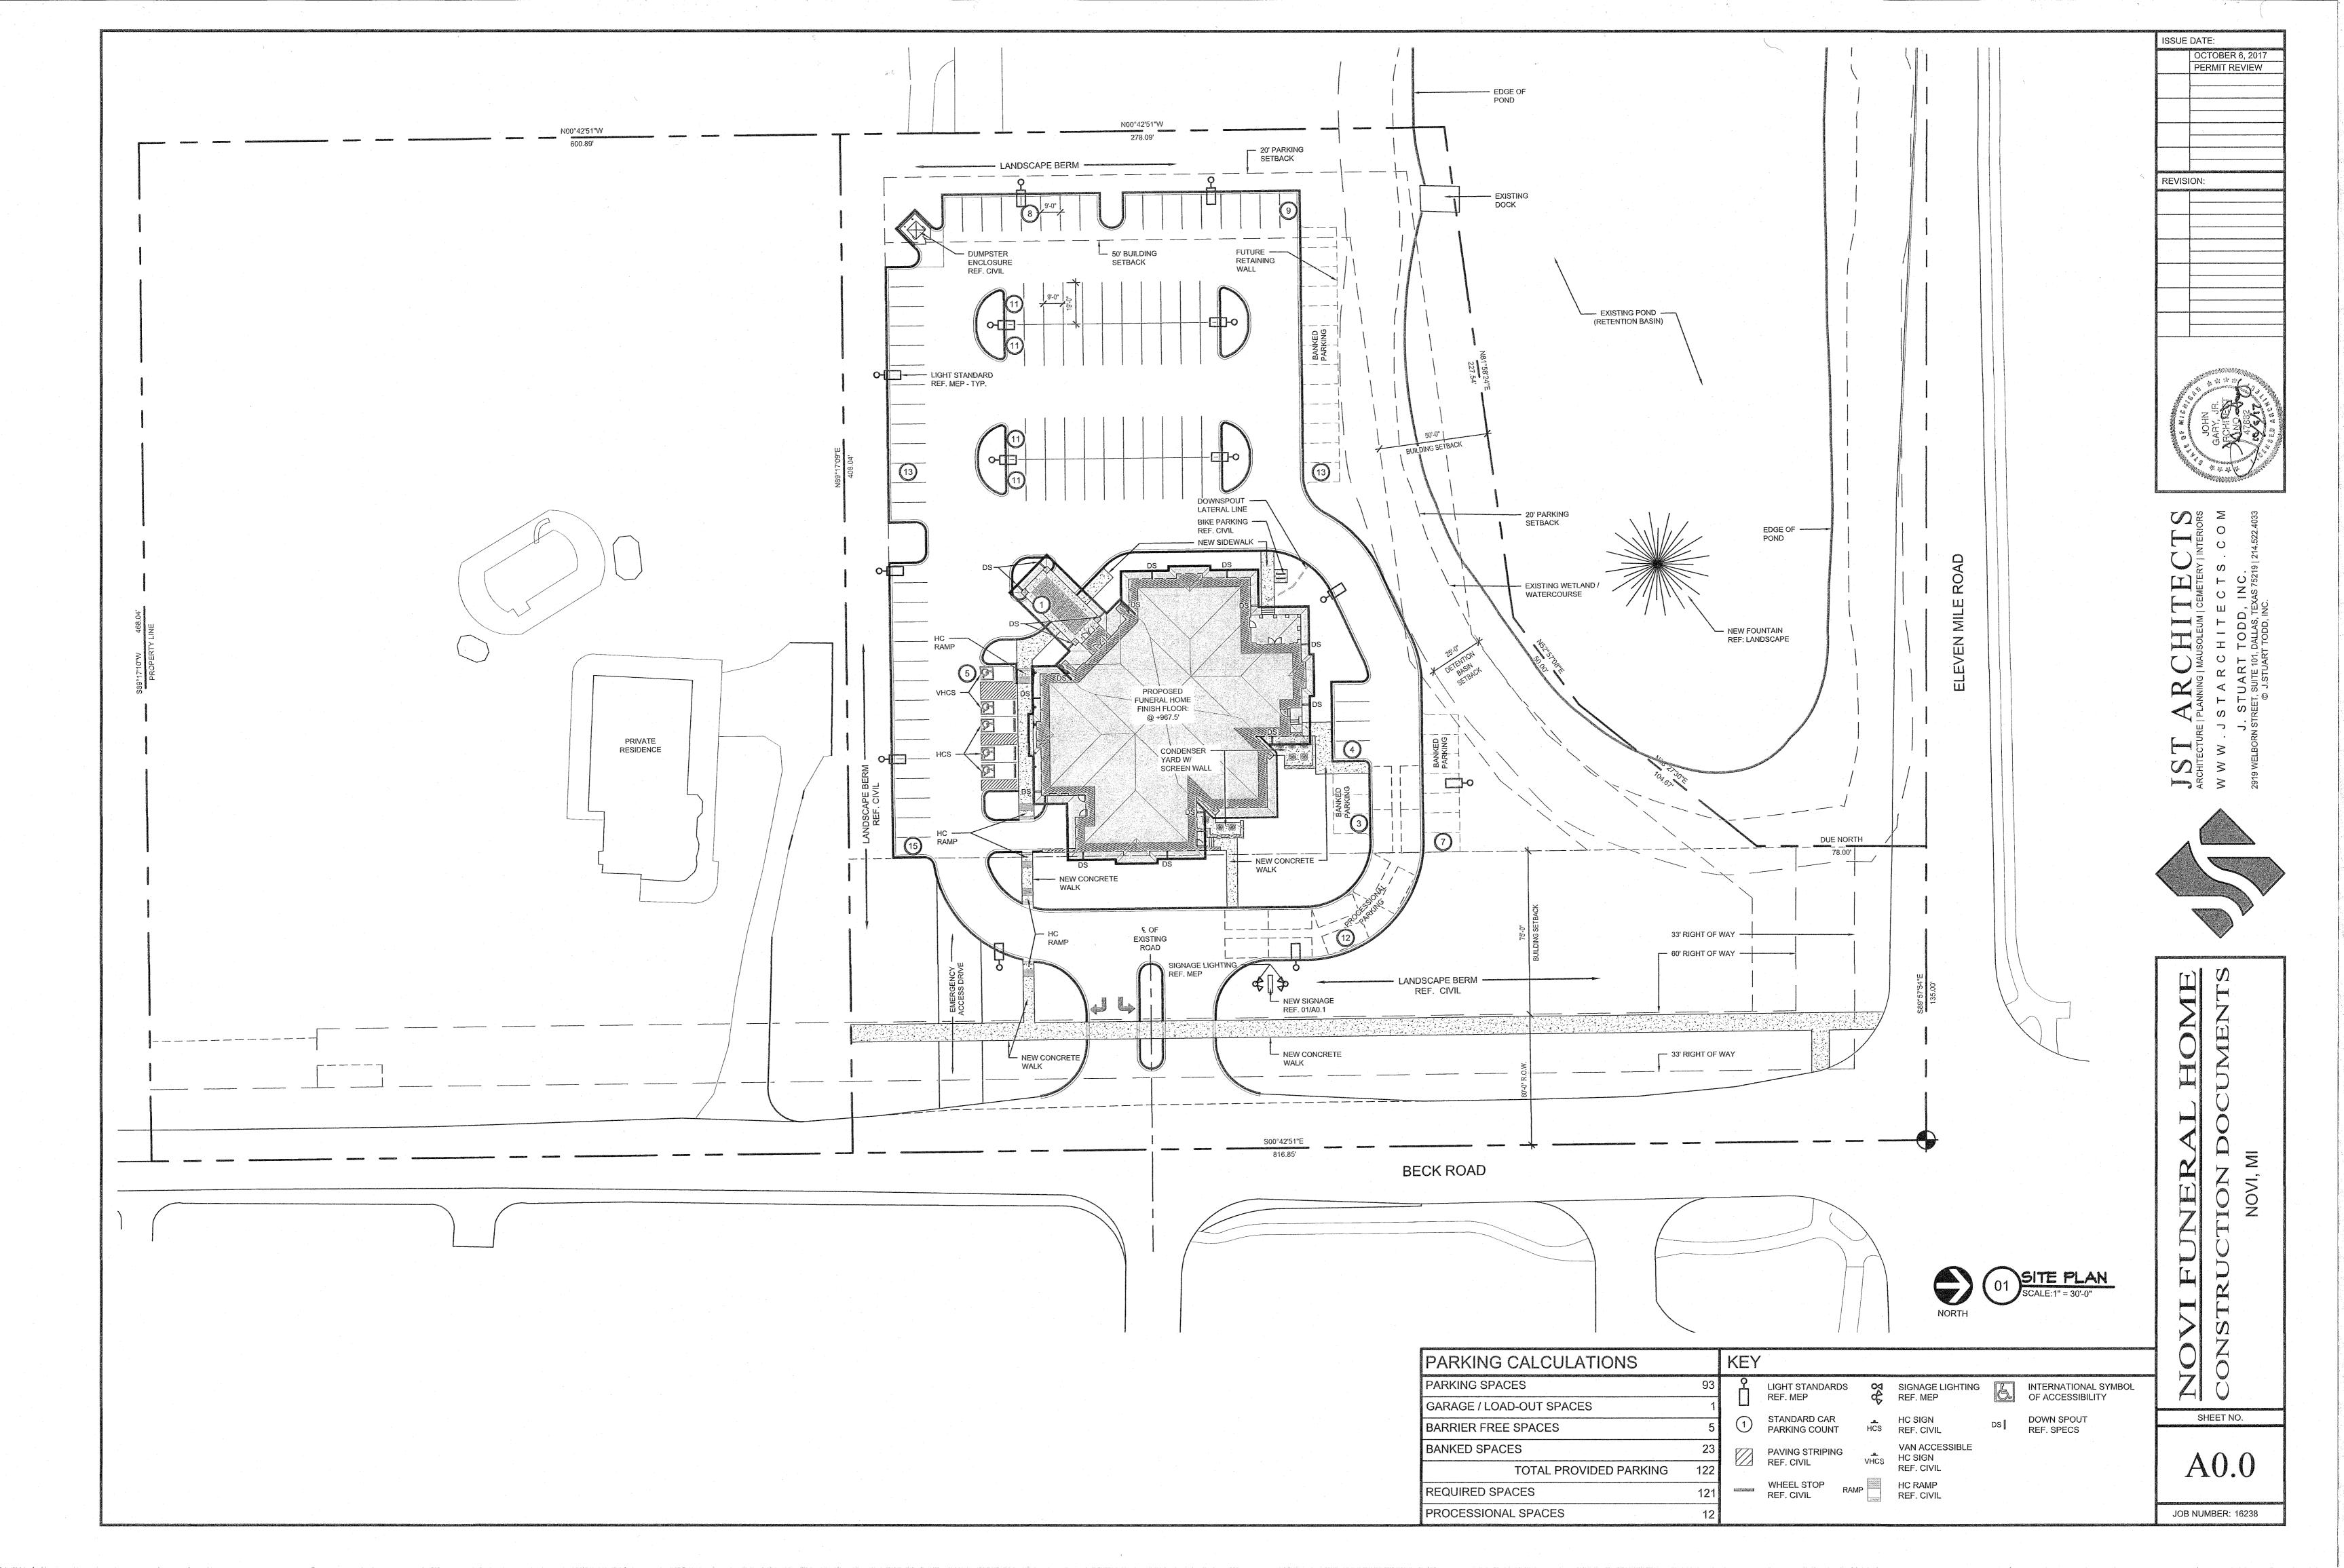



| | PERMIT REVIEW |
|-------------|--|
| | |
| | |
| | |
| | REVISION: |
| | |
| | |
| | |
| | |
| | market the same of |
| | |
| | N THE SECOND SEC |
| | |
| | |
| | NS ≥ SS |
| | ARCHINE CENTERY INTERIORS STARCHITECTS.COM STUART TODD, INC. STUART TODD, INC. STUART TODD, INC. © J.STUART TODD, INC. |
| | FTERY C C C C C C C C C |
| | T E O II S, TEXAS, TRACE |
| | TOLET, DALLA |
| | A R C JART SUITE 10: J.STUAR |
| | ARCHIE E PLANNING MAUSOLEUM CEMETER J S T A R C H I T E C T S J STUART TODD, INC. © J.STUART TODD, INC. |
| | ARCHITECTURE PLANNING MAUSOLEUM CEMETERY INTERIORS W W W J S T A R C H I T E C T S . C O M J. STUART TODD, INC. 2919 WELBORN STREET, SUITE 101, DALLAS, TEXAS 75219 214.522.4033 © J.STUART TODD, INC. |
| | N W V |
| | \ \ \ \ \ \ \ \ \ \ \ \ \ \ \ \ \ \ \ |
| | |
| | |
| | |
| | |
| | |
| | SEN J |
| | |
| | |
| > | |
| | |
| 2 | TONERAL HOME UCTION DOCUMENTS NOW, MI |
| 2'-0" | NOVI, M |
| | |
| | LB |
| 2-8" | |
| | IST TST |


7" APPLIED LETTERS -CAST STONE CAP 'F' REF. 02/A1.0 5" APPLIED LETTERS -TOP OF WALL TOP OF WALL Griffin Funeral Home BRICK VENEER TO ——— MATCH BUILDING METAL THROUGH —/ FLASHING 8" CMU BOND BEAM REF. STRUCTURAL 4" BRICK VENEER
W/ BRICK TIES @ 16" O.C.
VERTICALLY AND 24" O.C. APPLIED LETTERS
BOTH SIDES
REF. SIGN ELEVATION 4" STONE VENEER WATER TABLE
W/ BRICK TIES @ 16" O.C.
VERTICALLY AND 24" O.C. FULLY GROUTED 4"
CMU MASONRY WALL
REF. STRUCT. STONE WATER TABLE — TO MATCH BUILDING TOP OF FOUNDATION TOP OF FOUNDATION 12" STRUCTURAL CMU WALL PROVIDE WEEP HOLES @ 24" O.C. 8'-0" NOTE: SAME ELEVATION BOTH SIDES.

A0.1

SHEET NO.

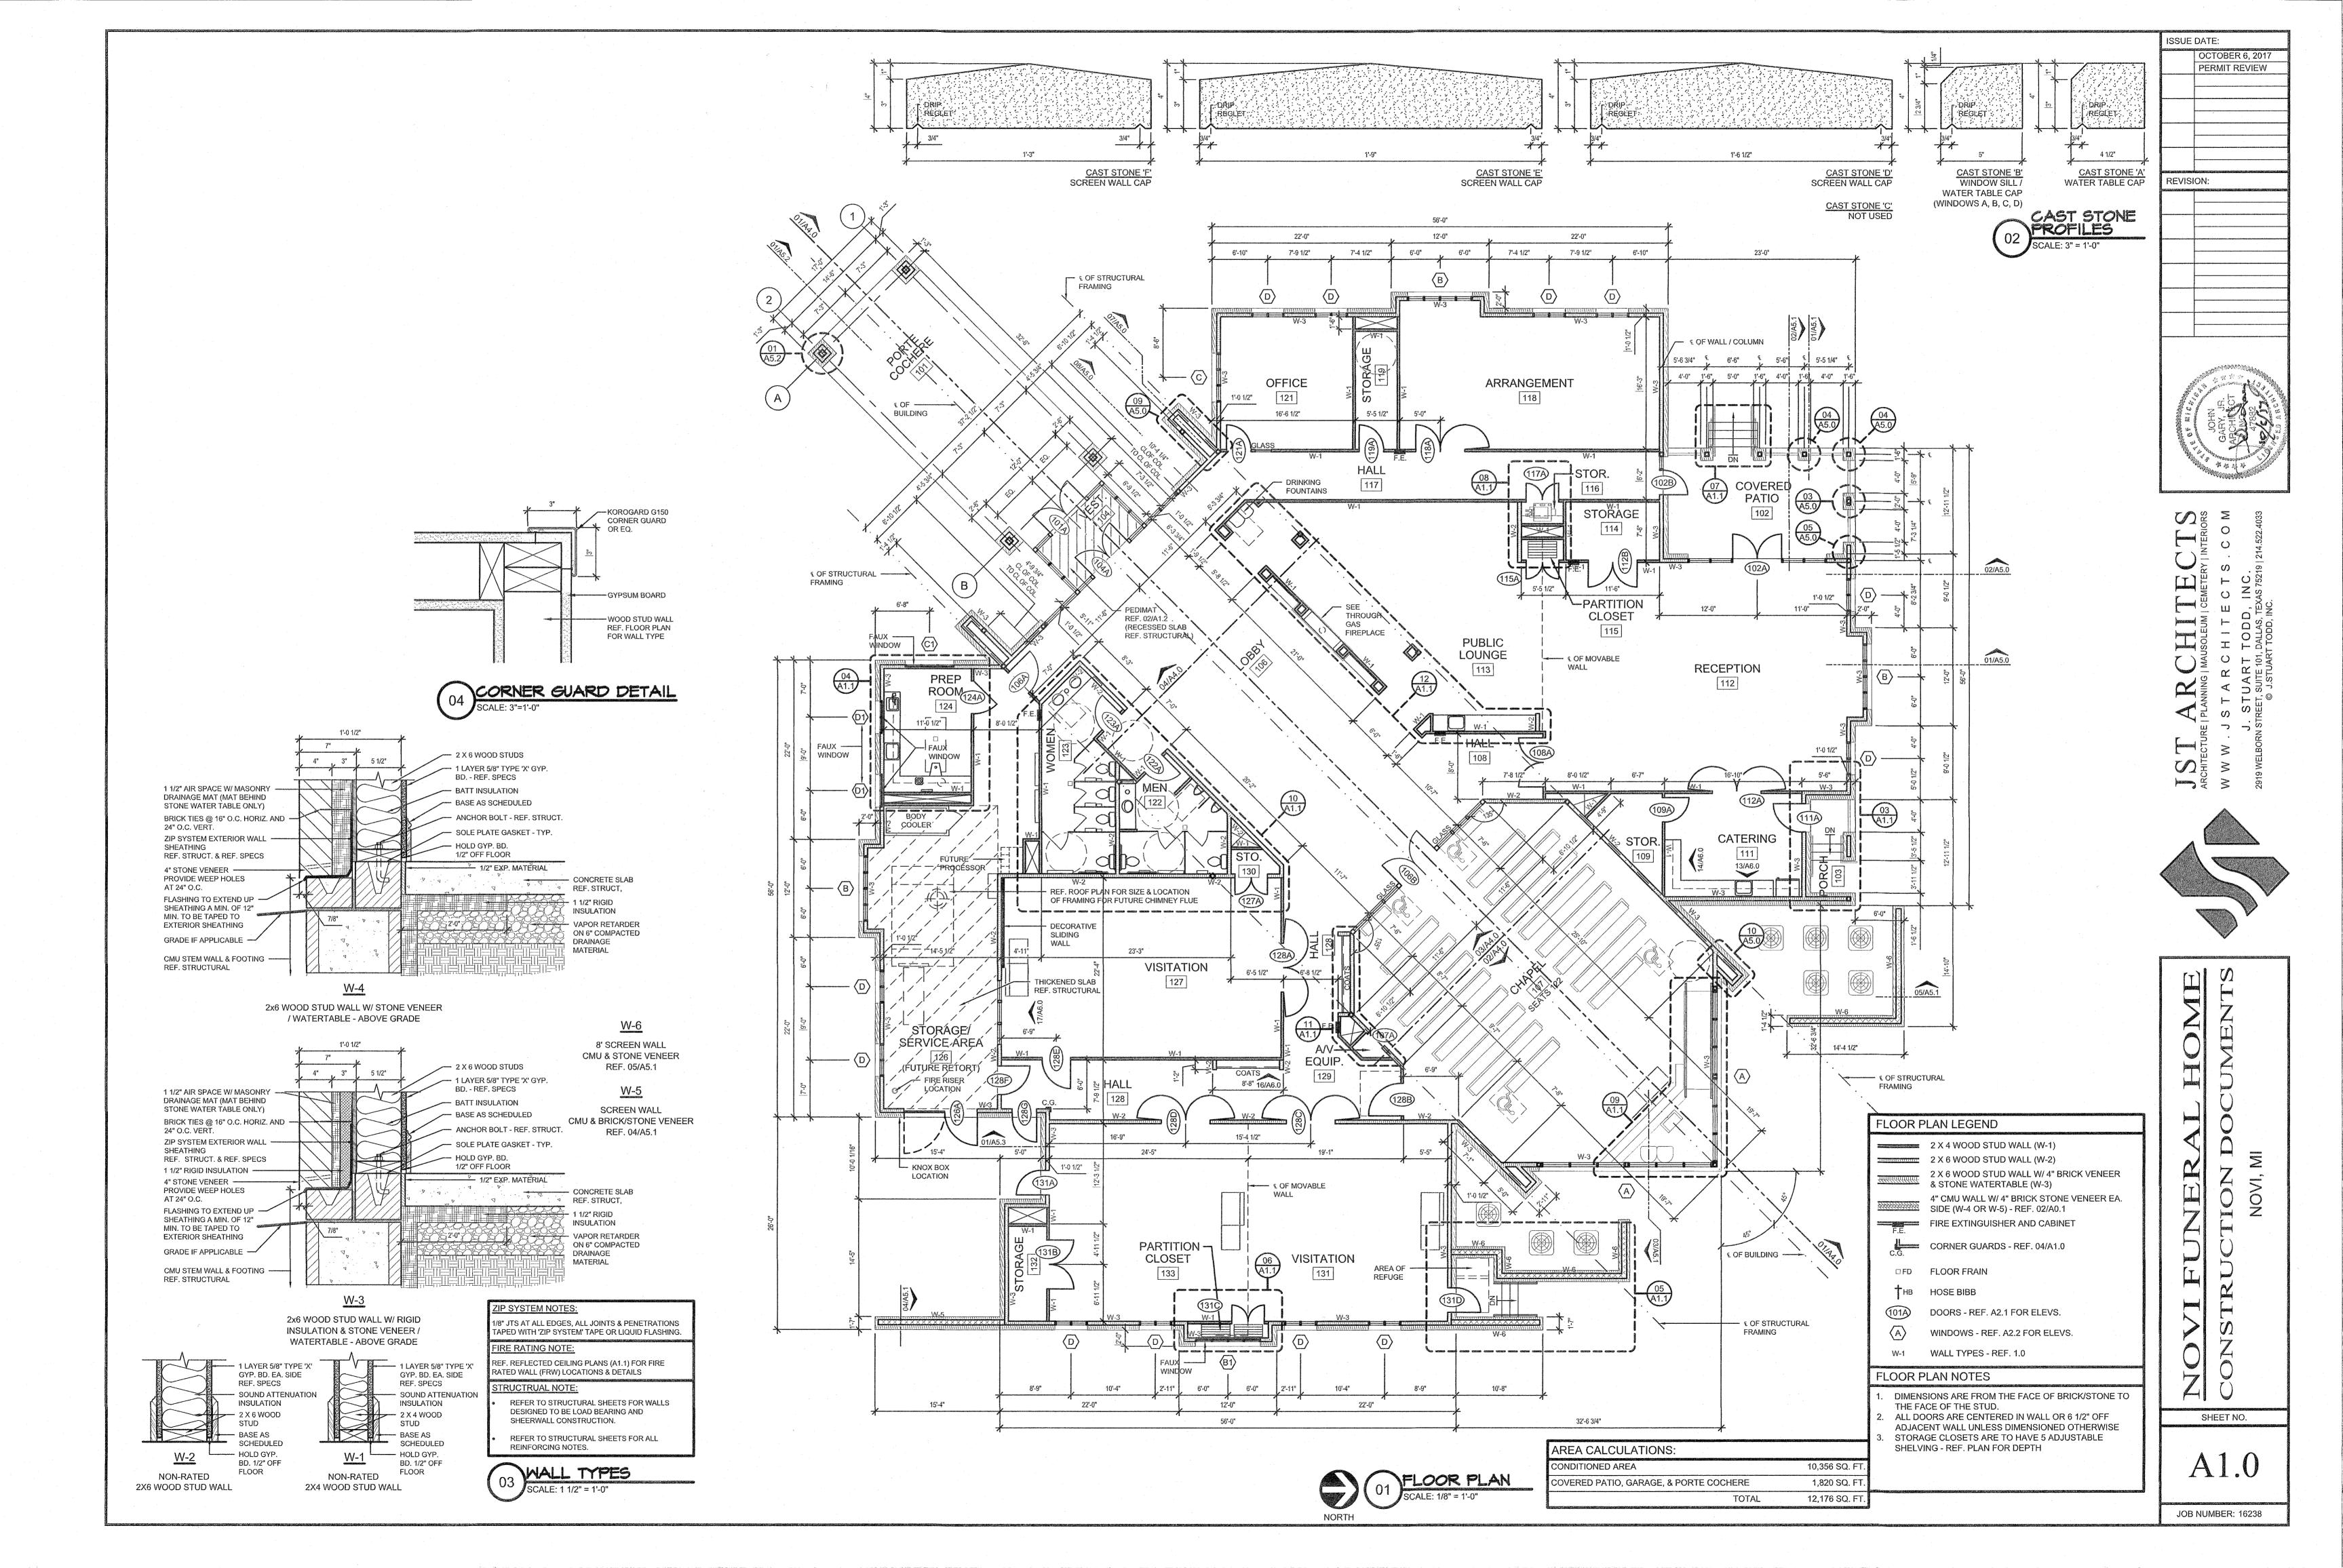

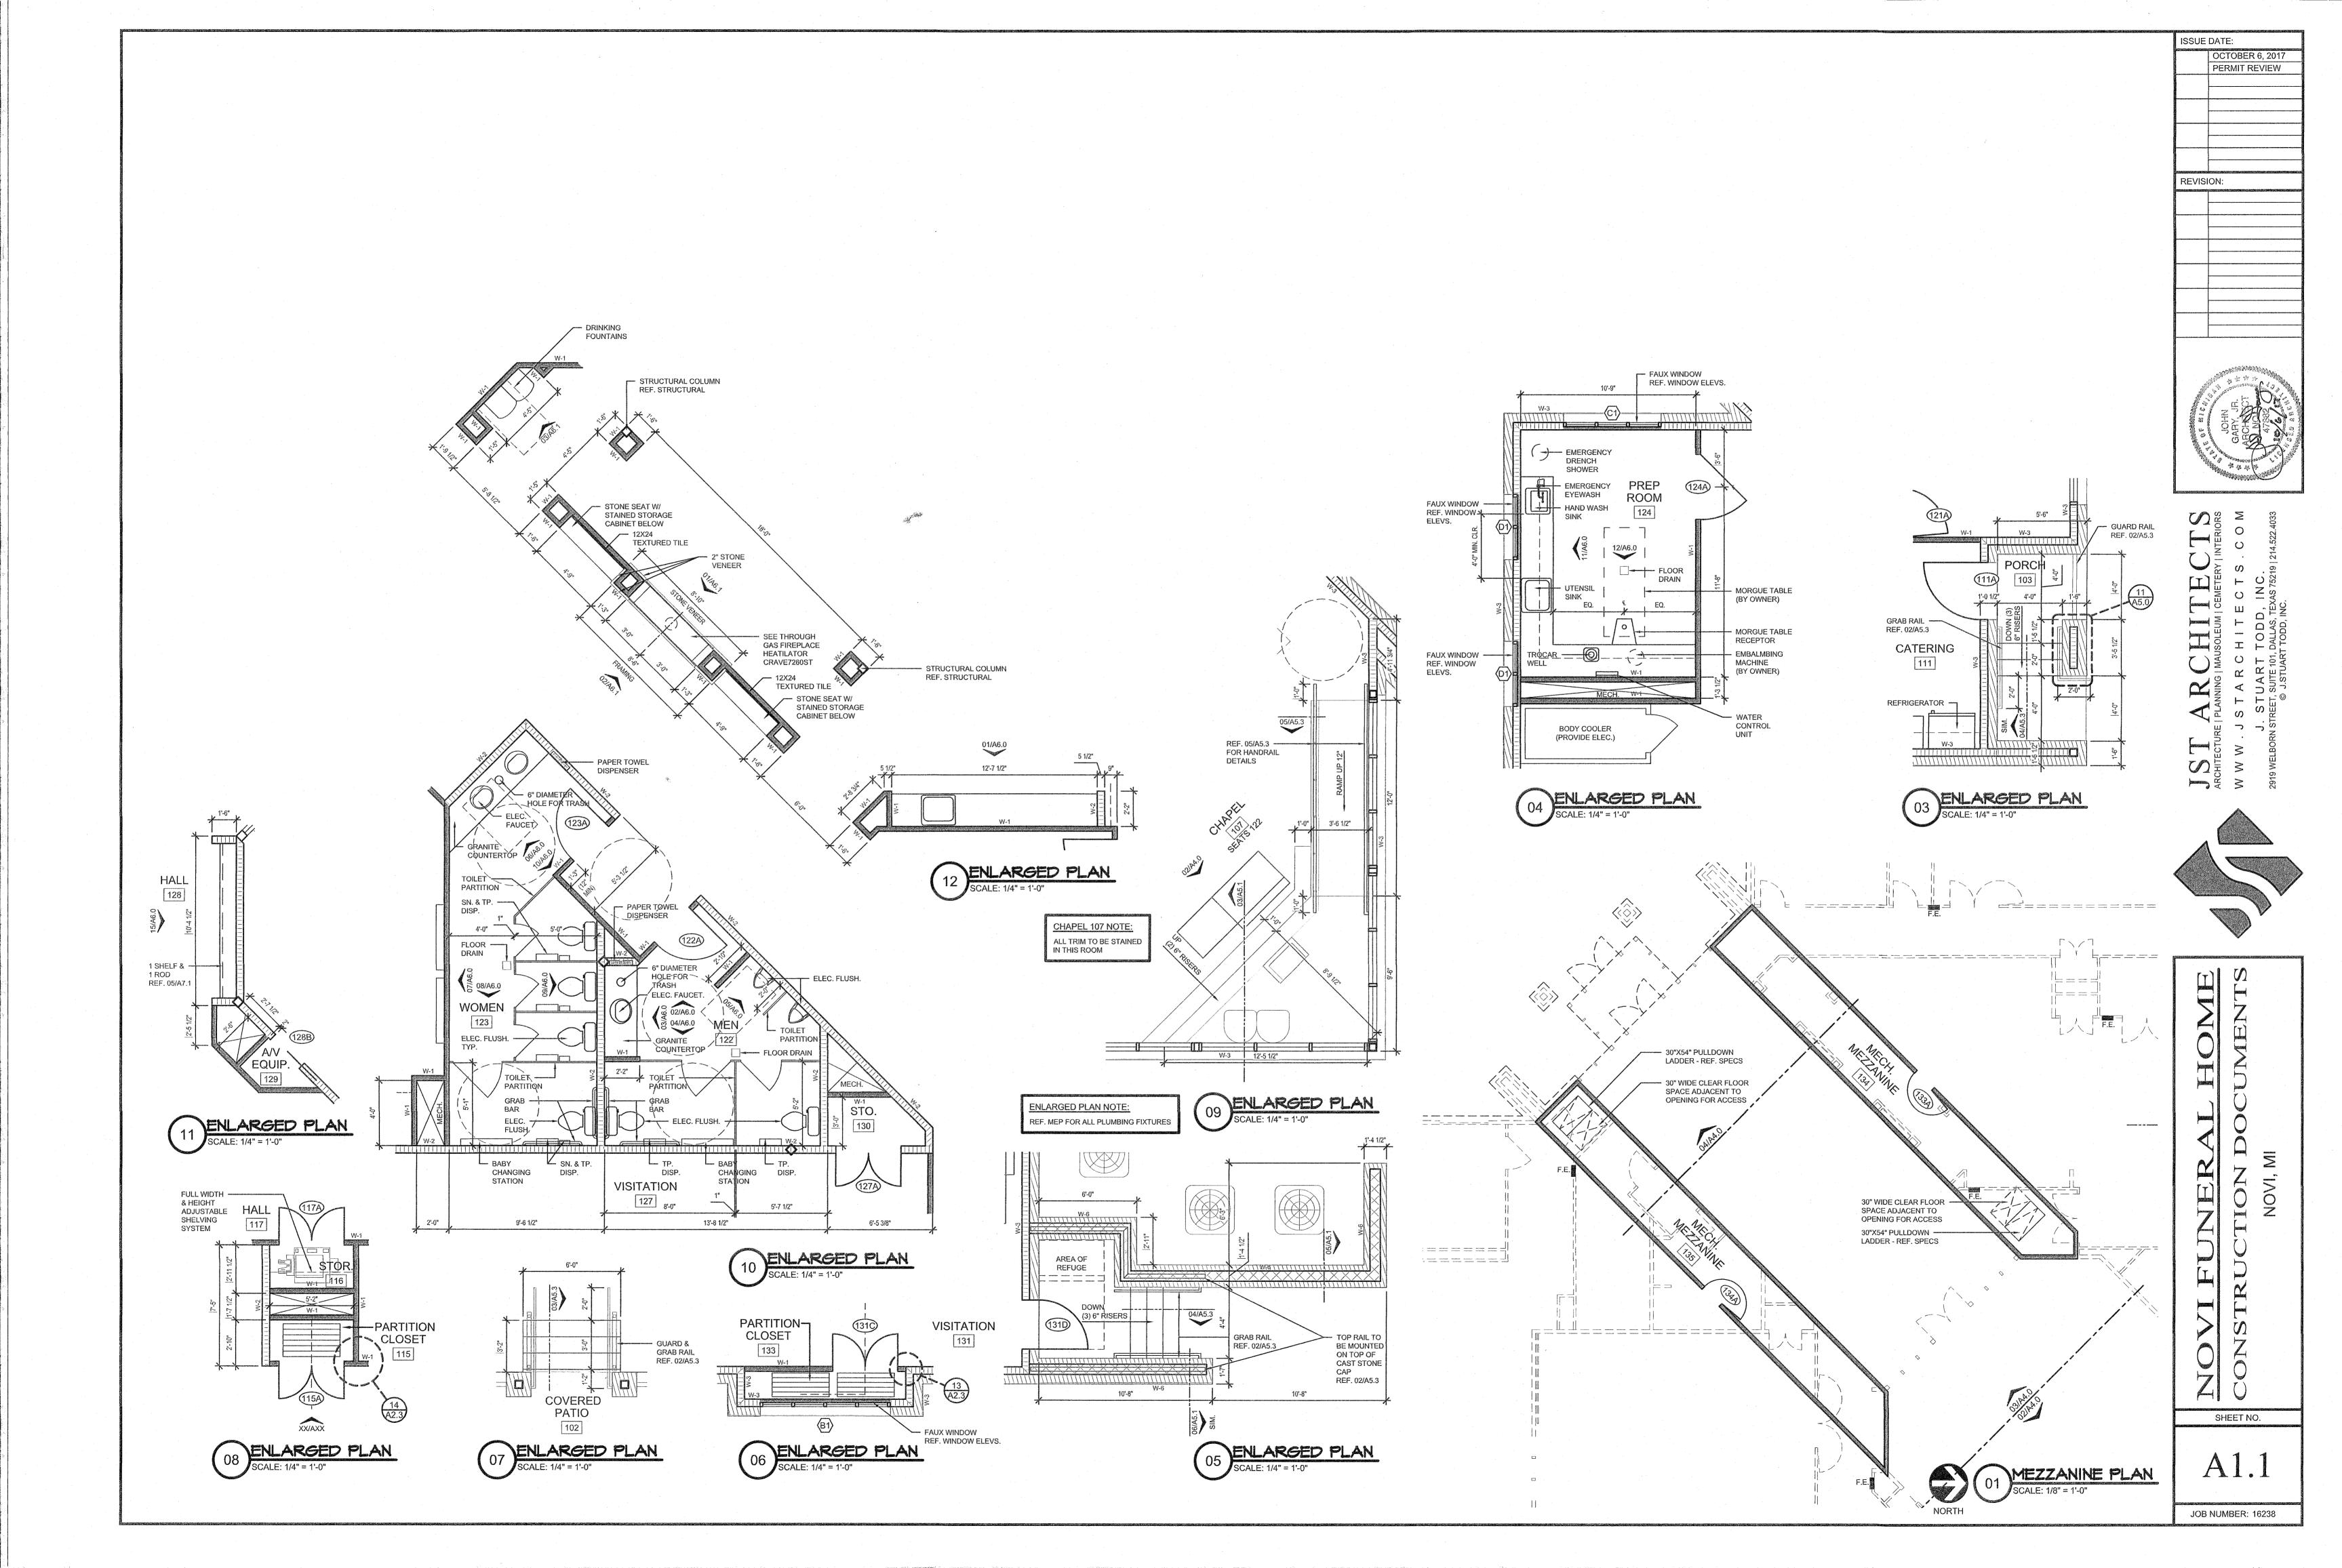


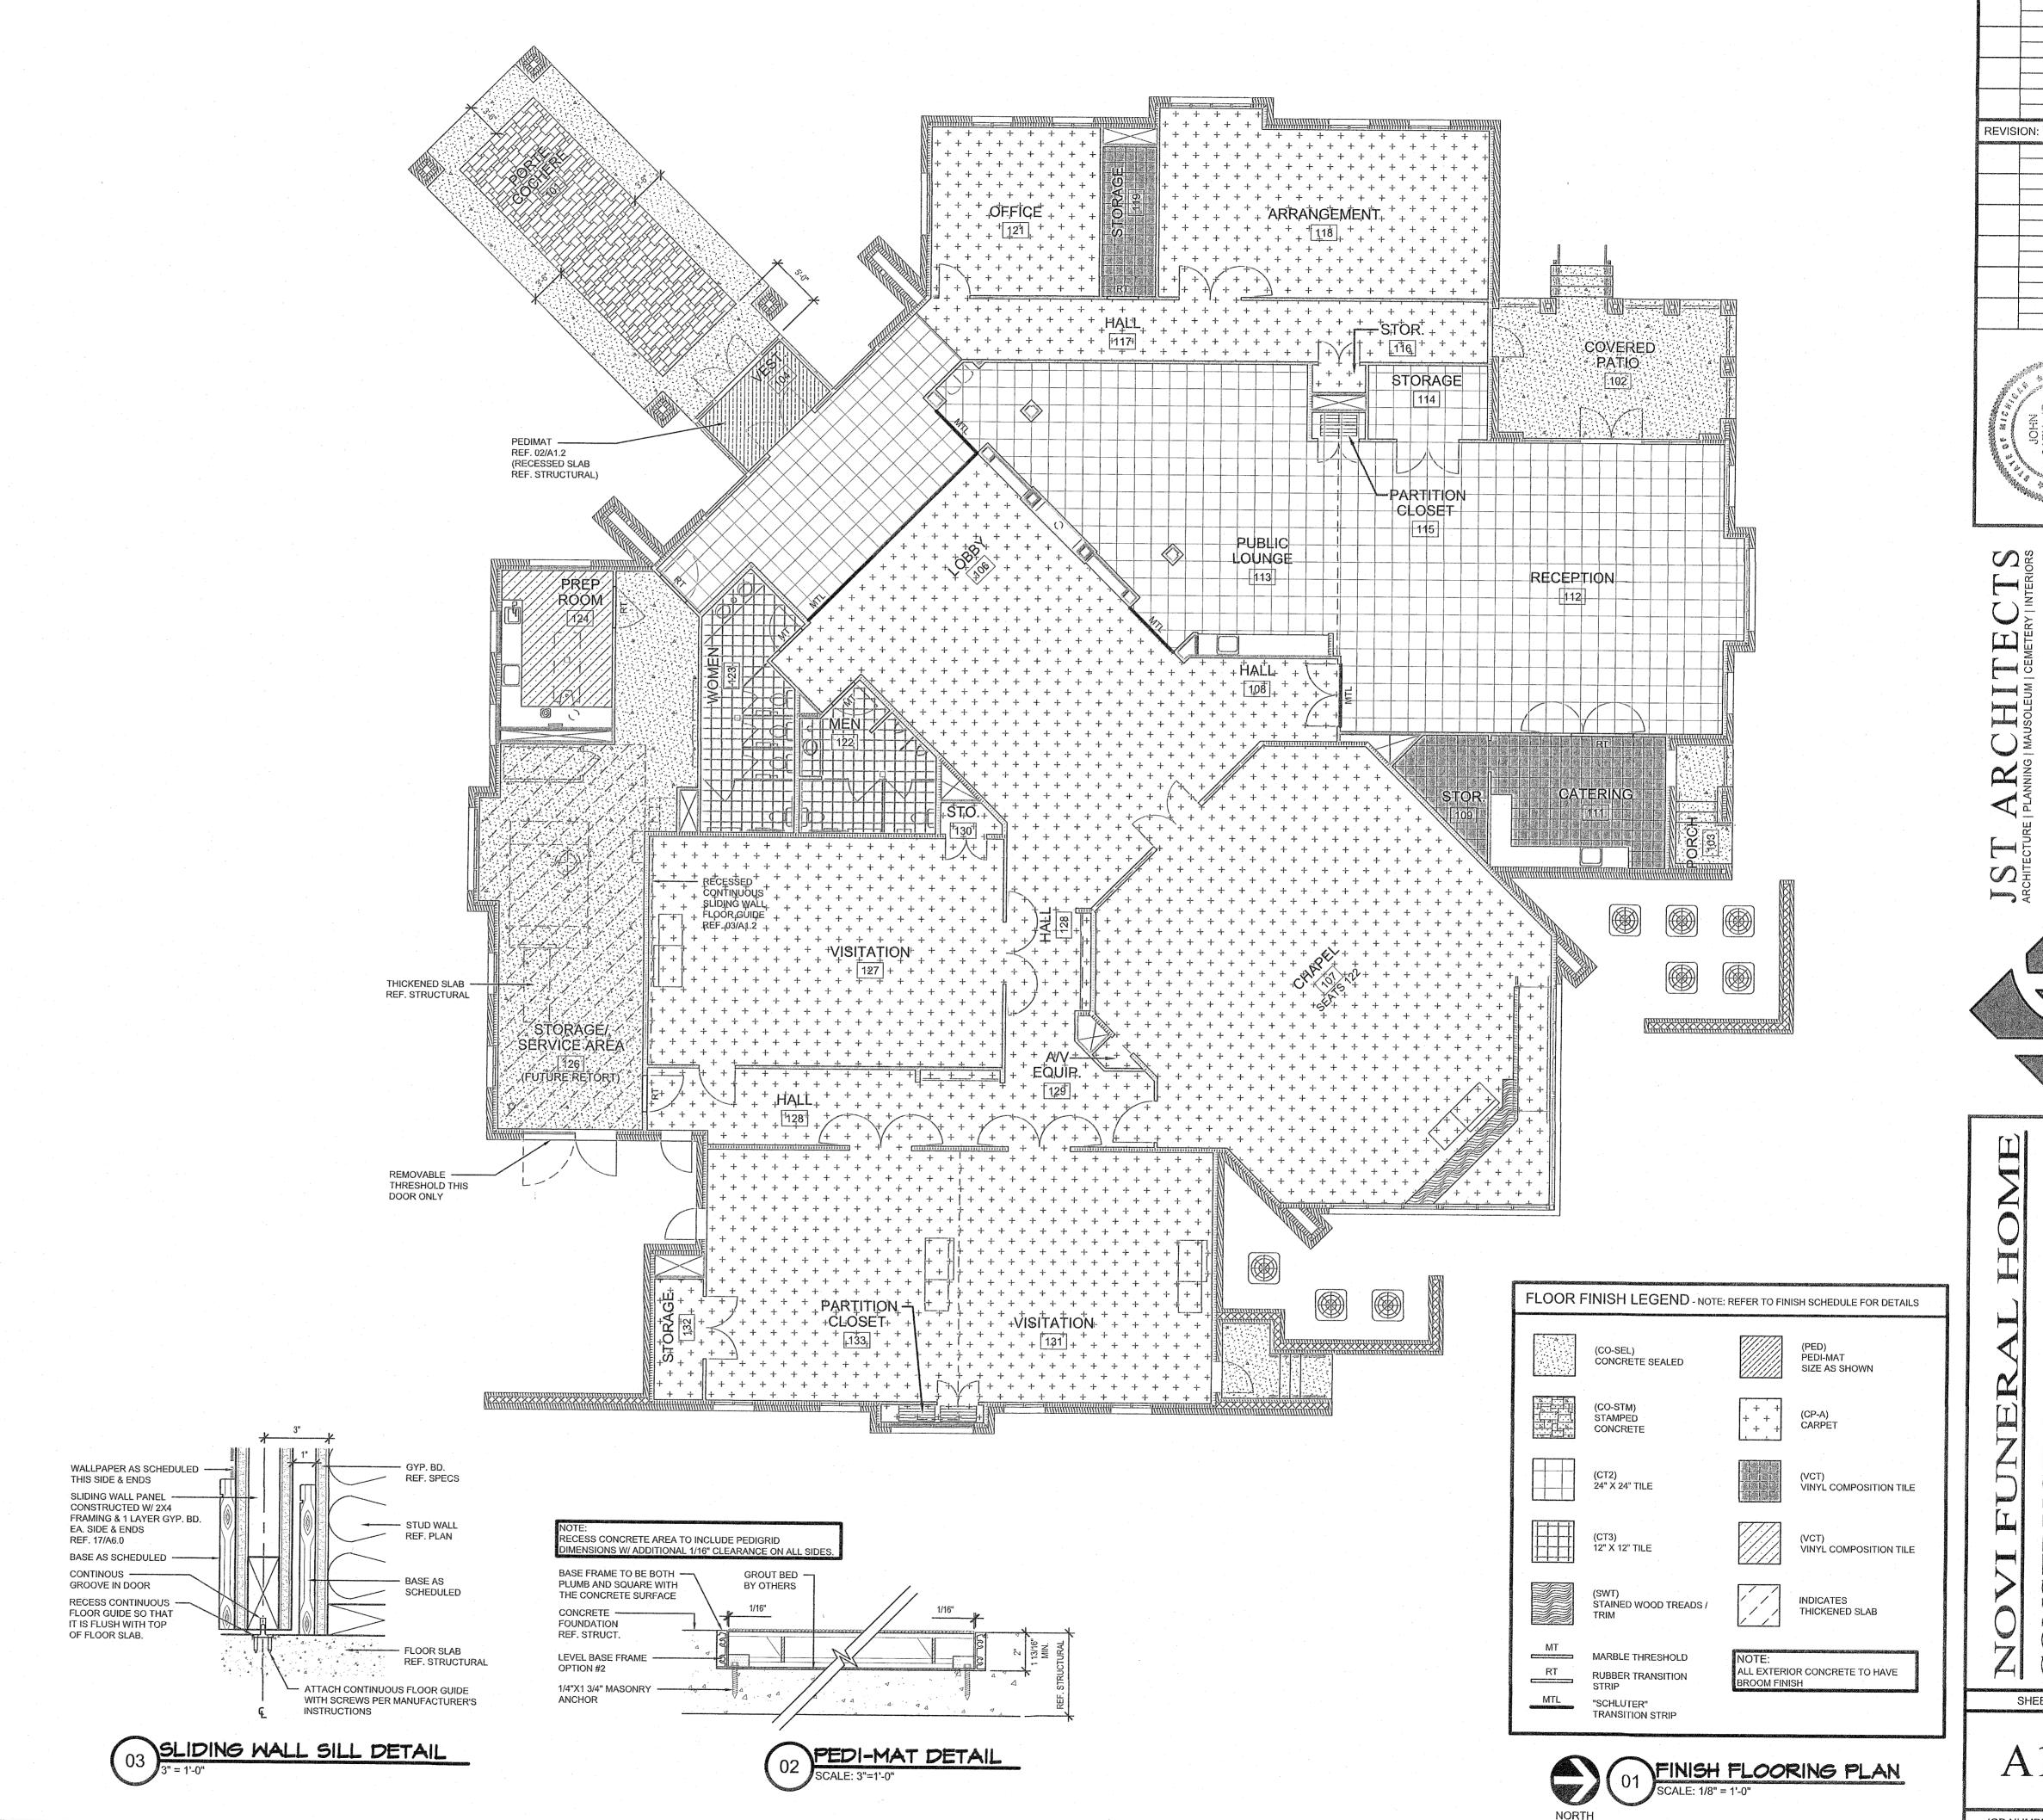



ISSUE DATE:


OCTOBER 6, 2017 PERMIT REVIEW

70 SHEET NO. A1.2

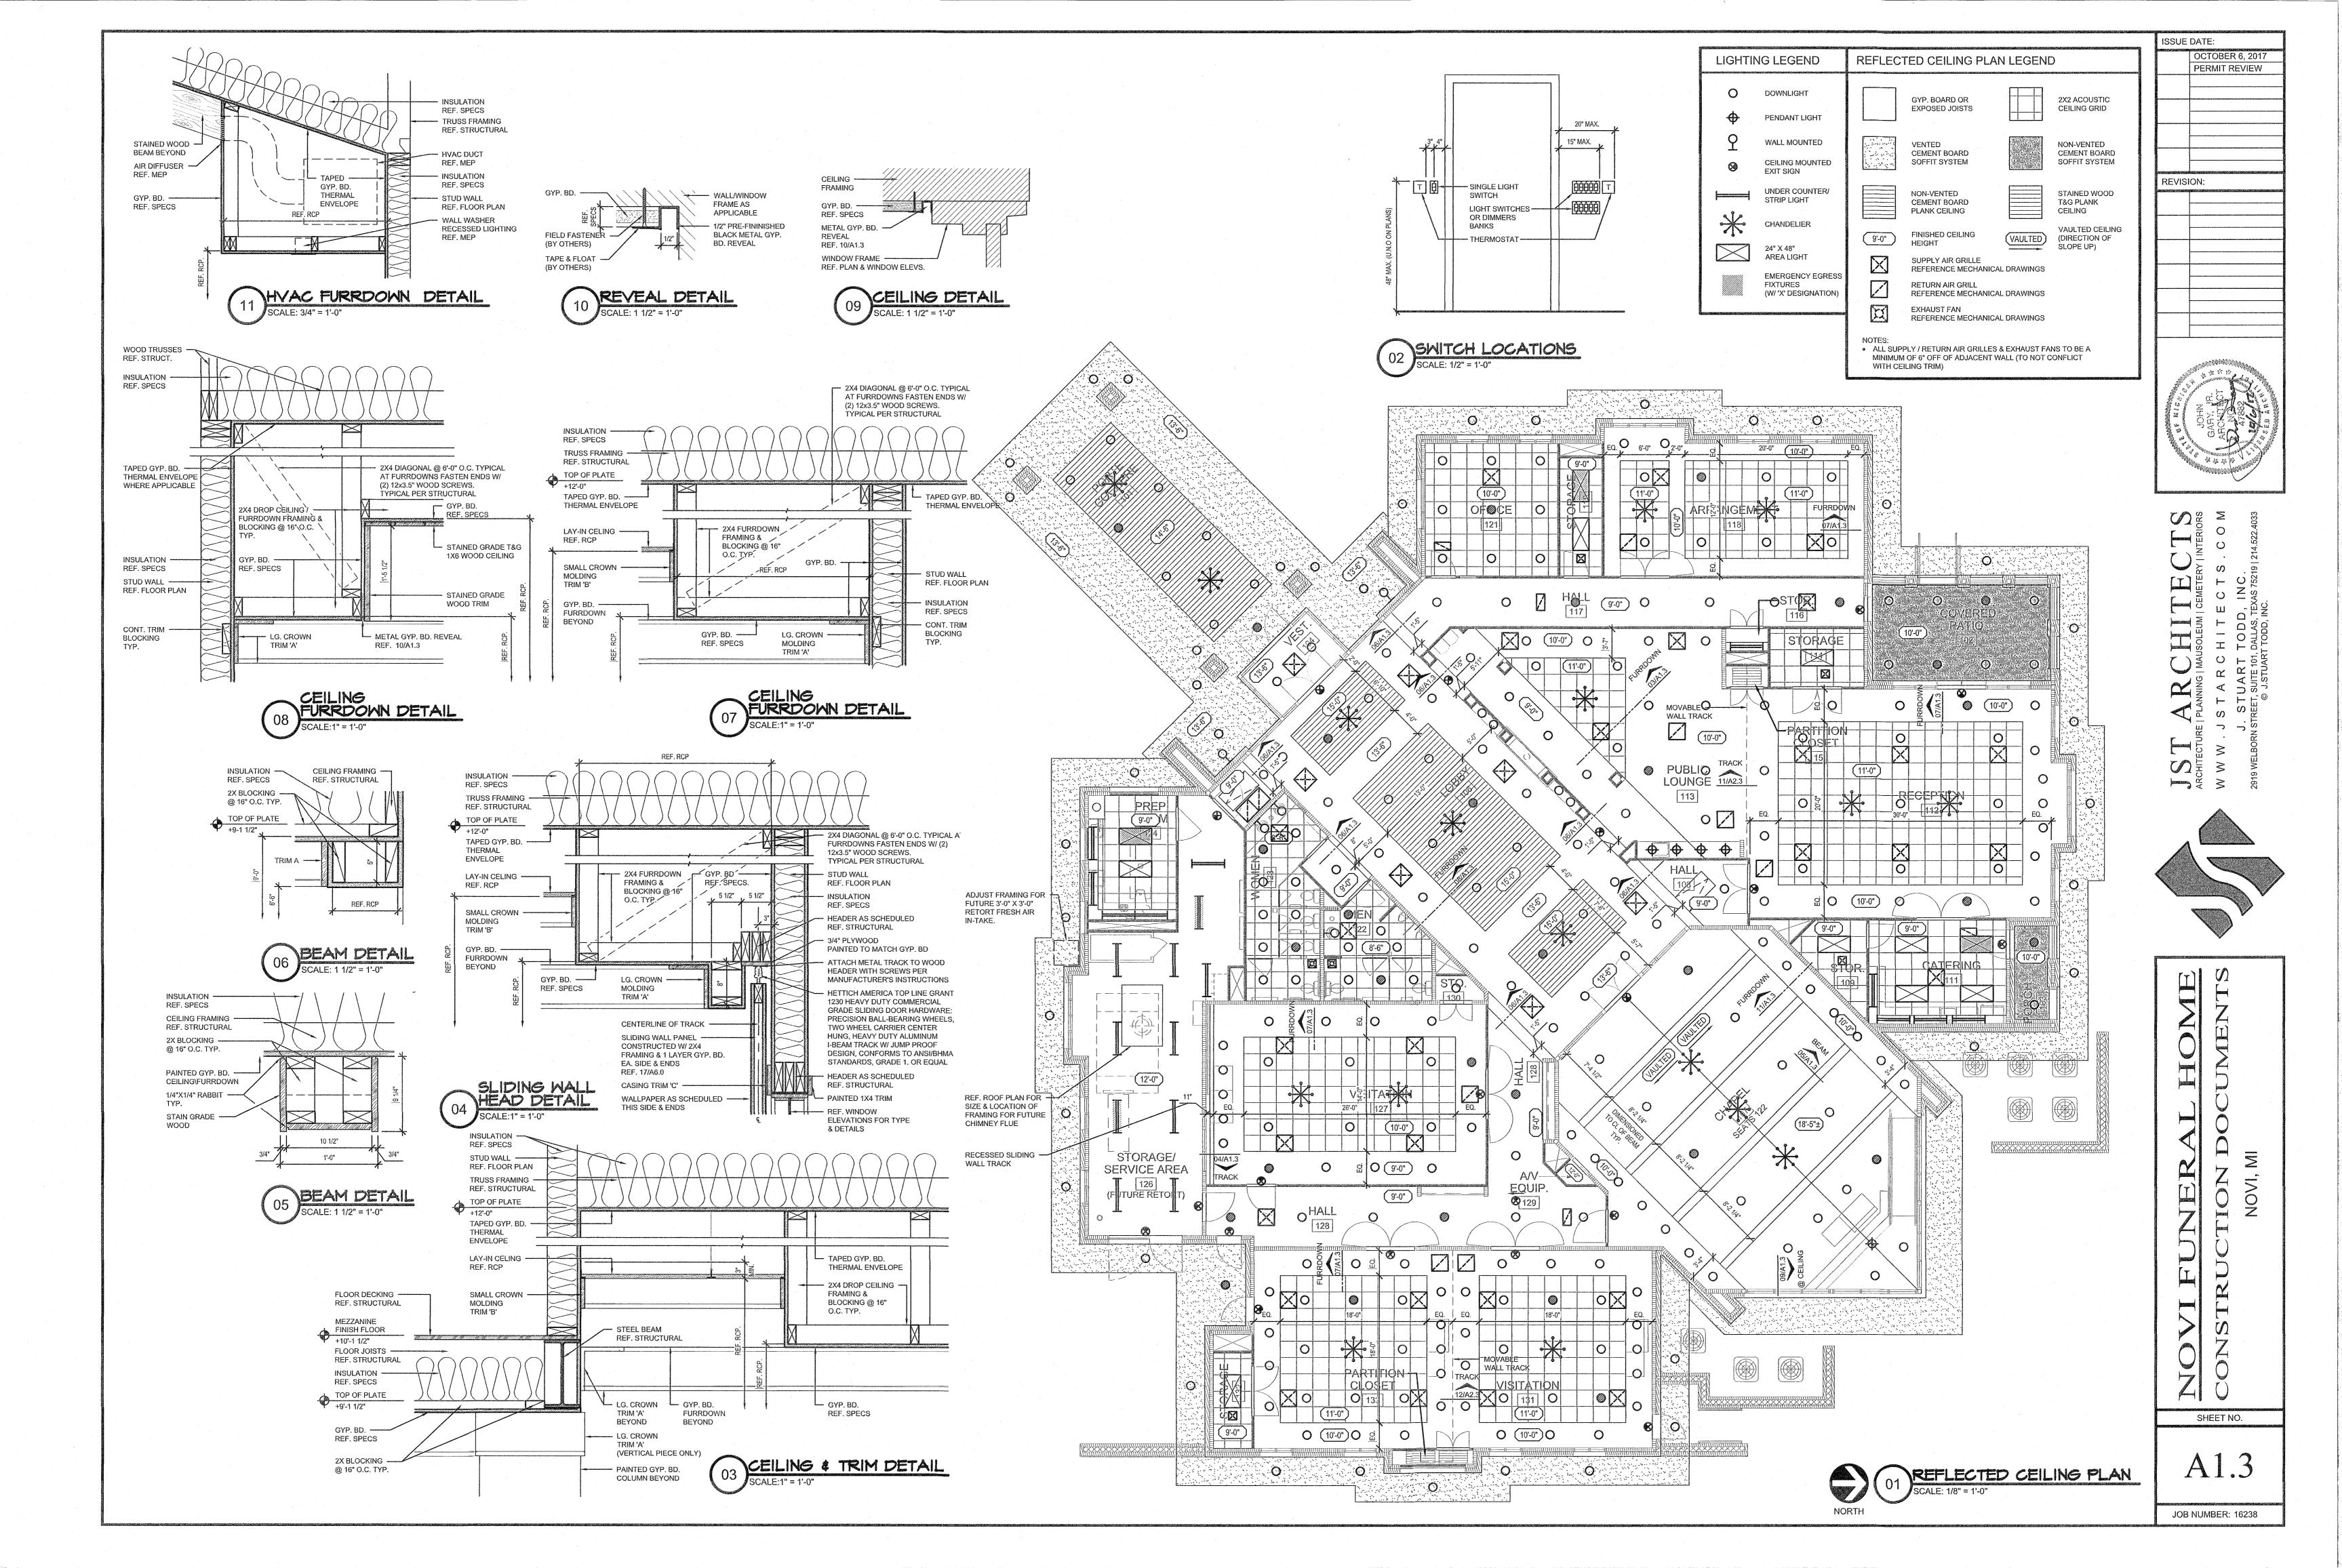

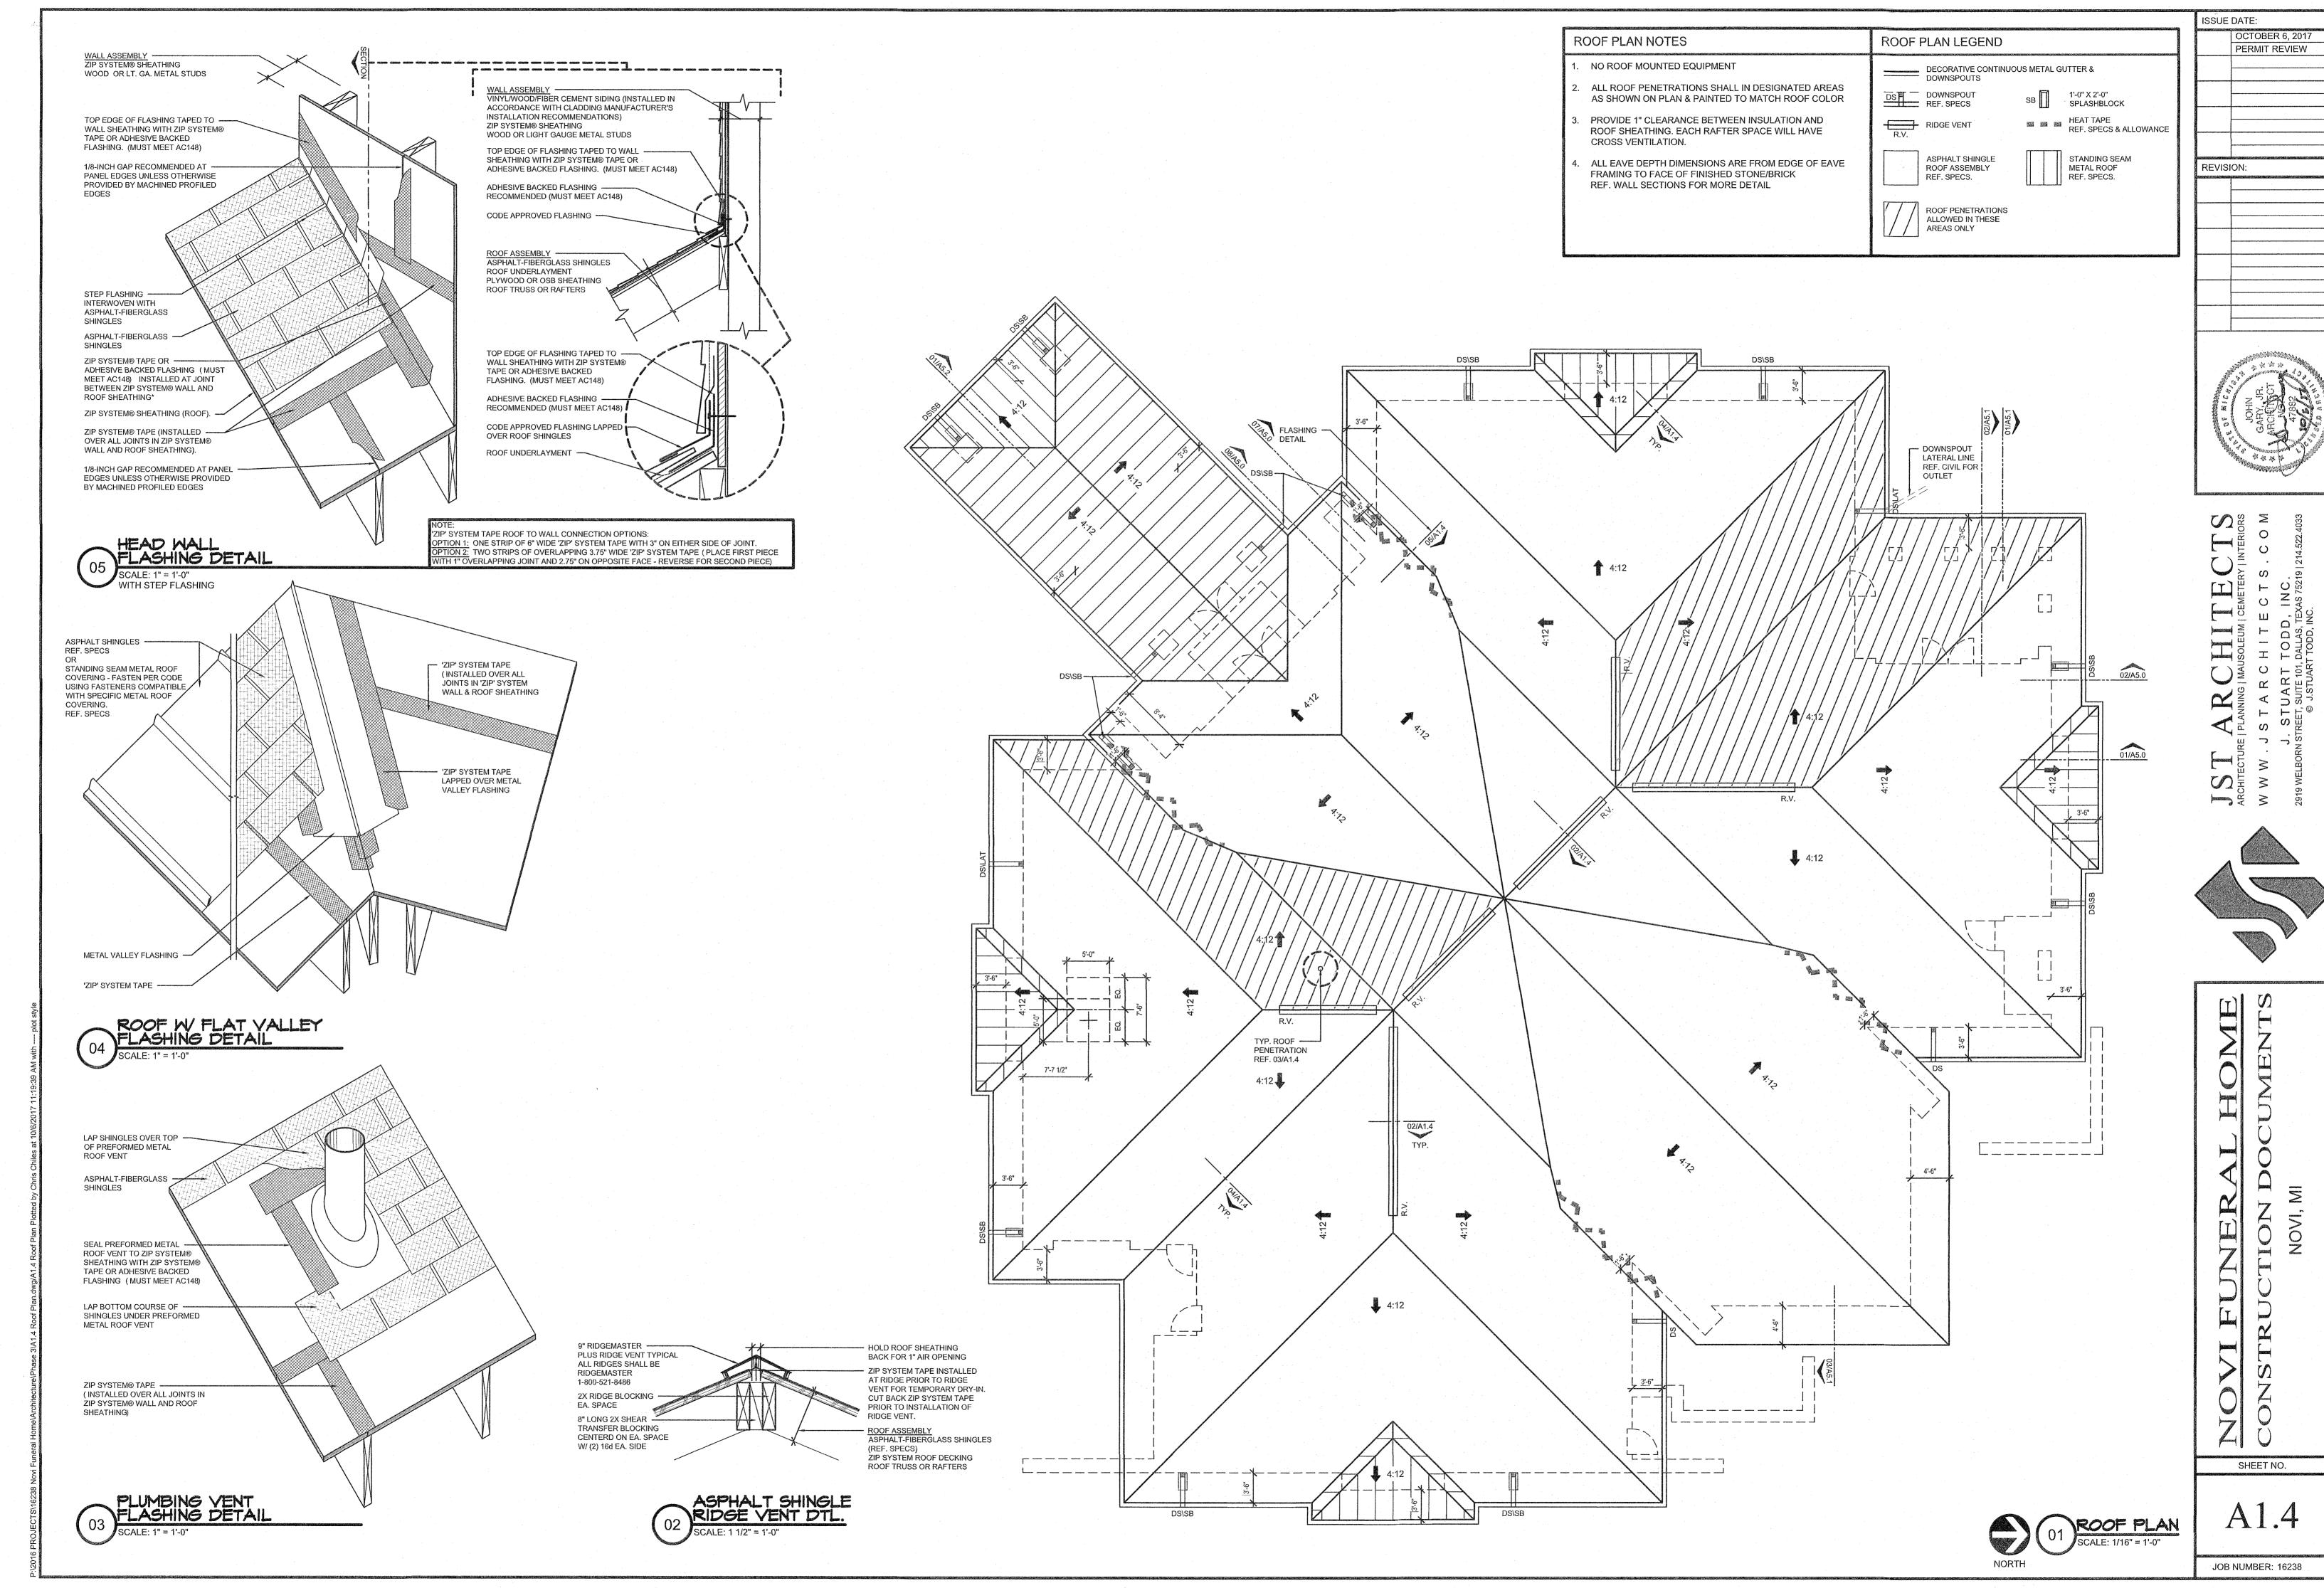

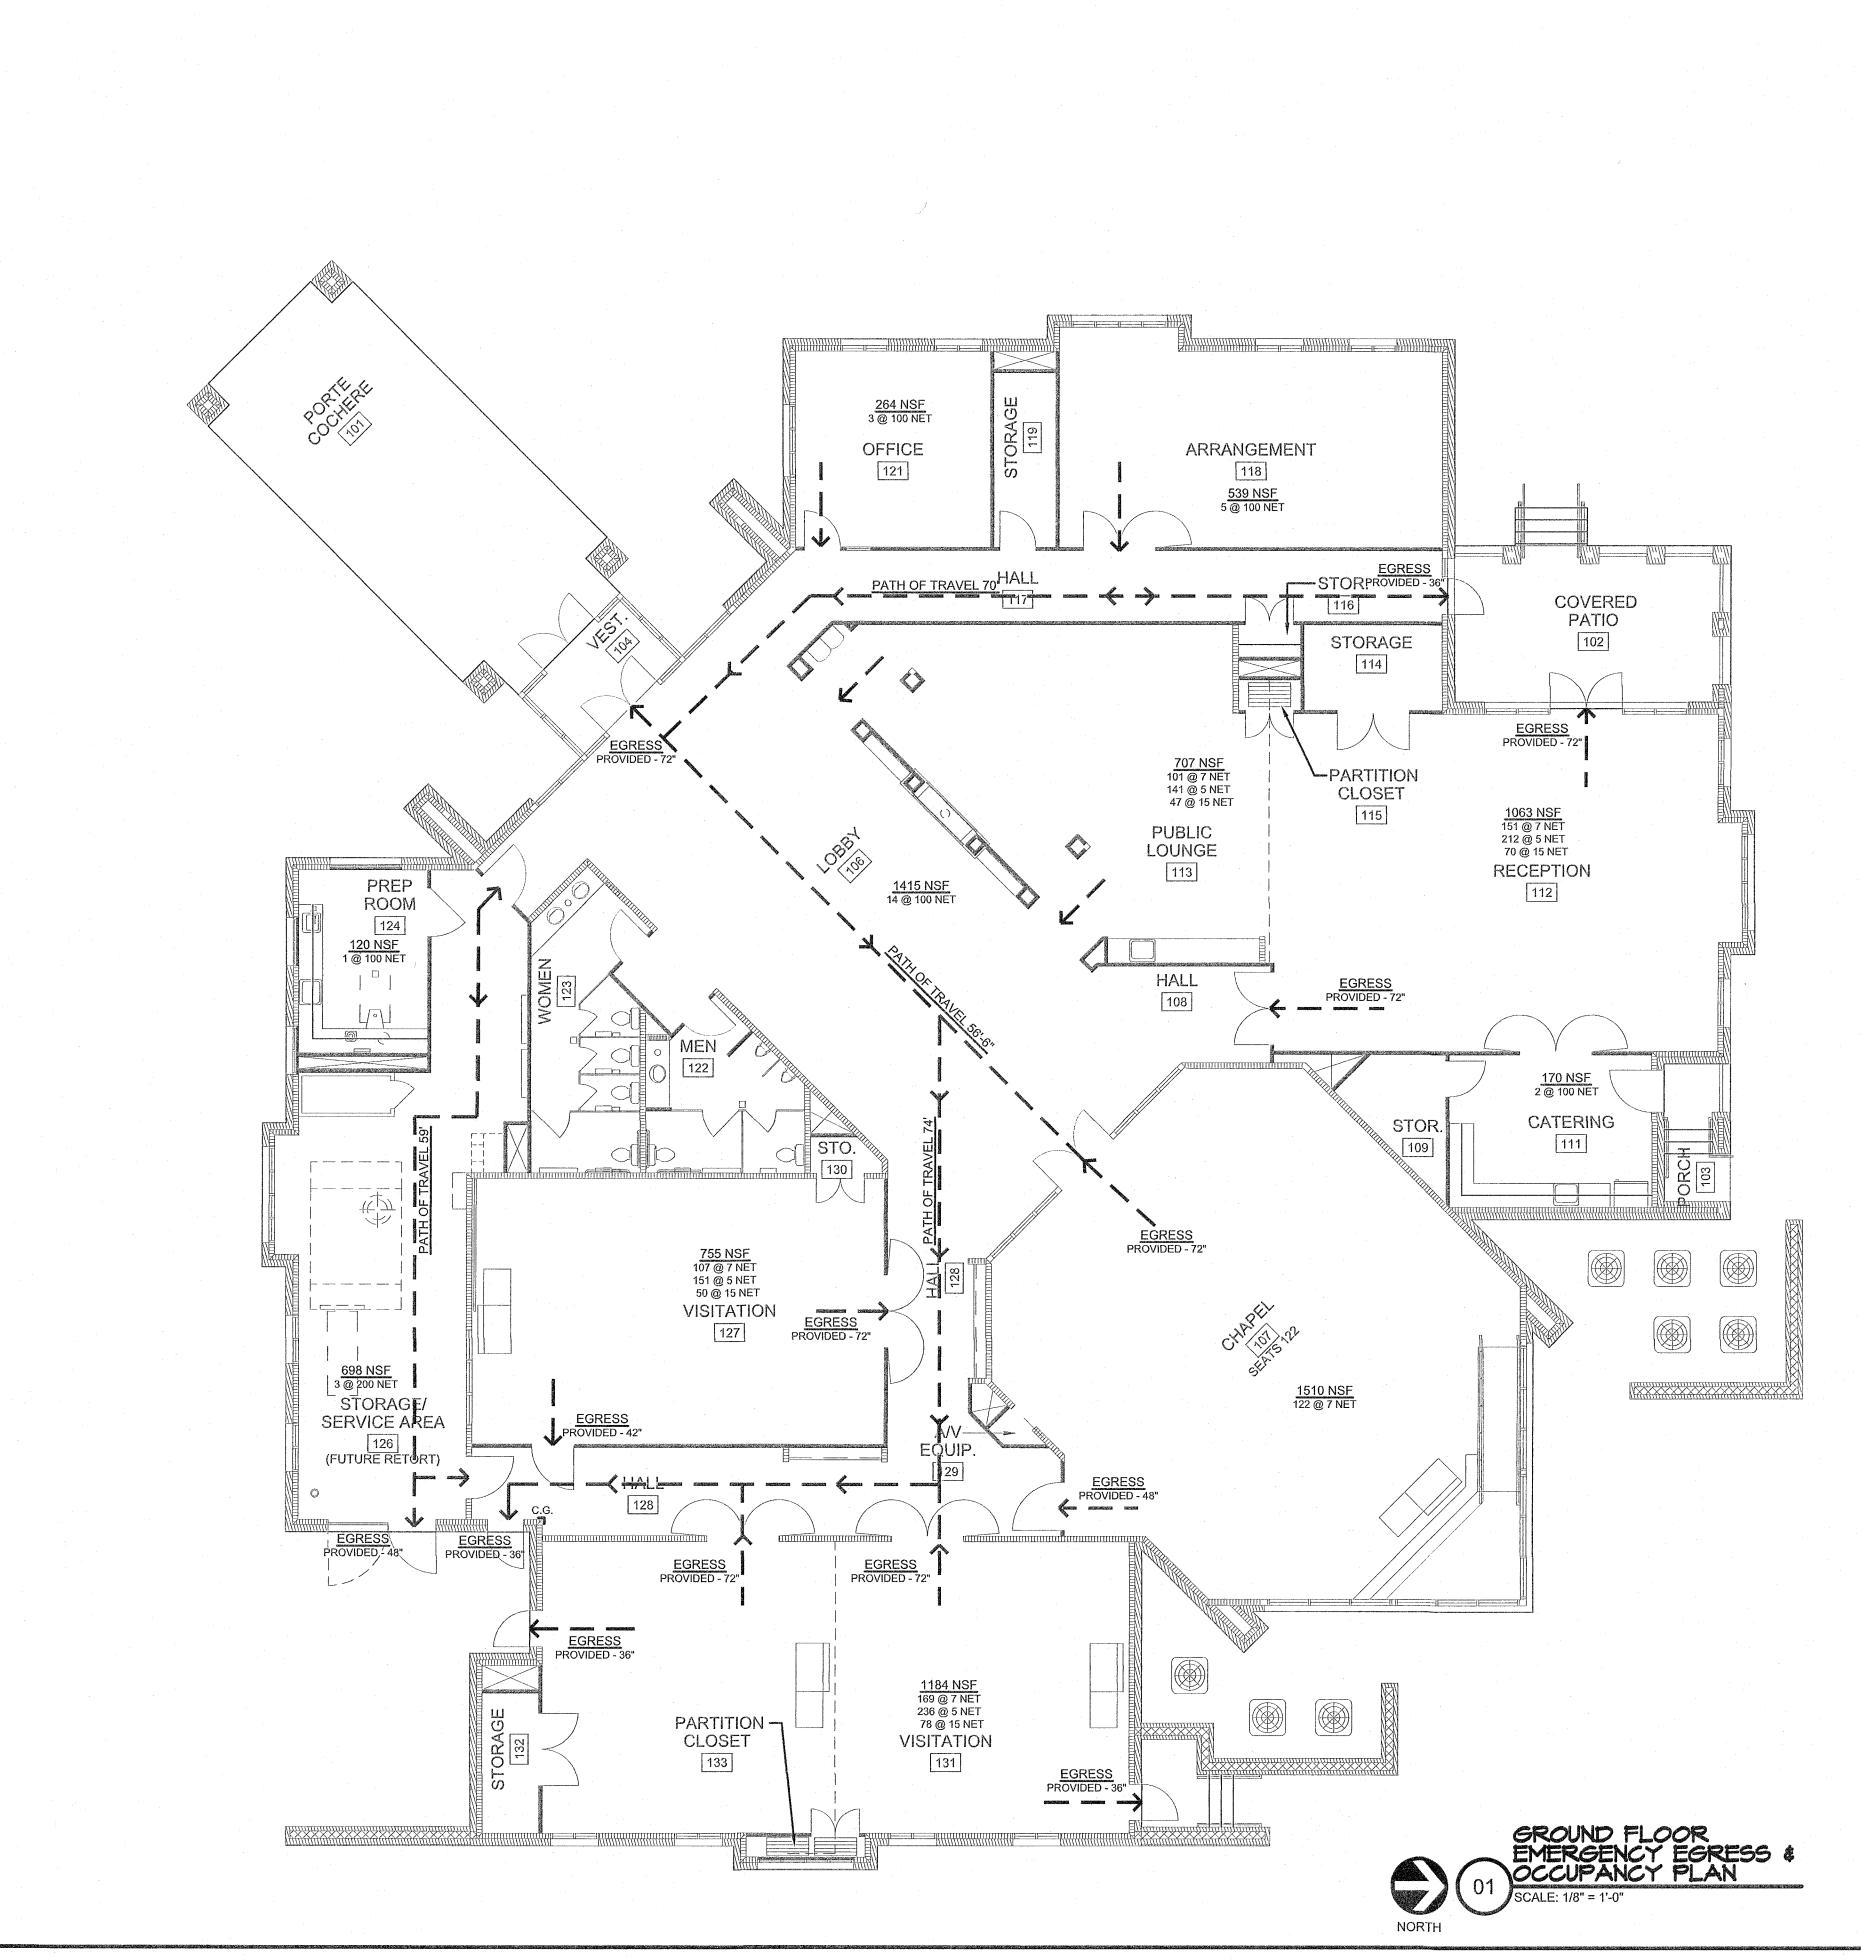


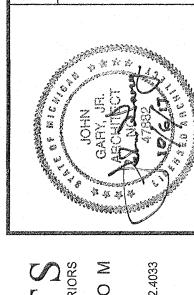

ISSUE DATE:

OCTOBER 6, 2017
PERMIT REVIEW



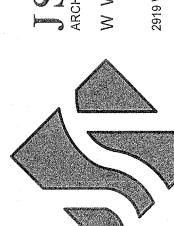



TOME


CONSTRUCTION DOCUME

SHEET NO.

A1.5

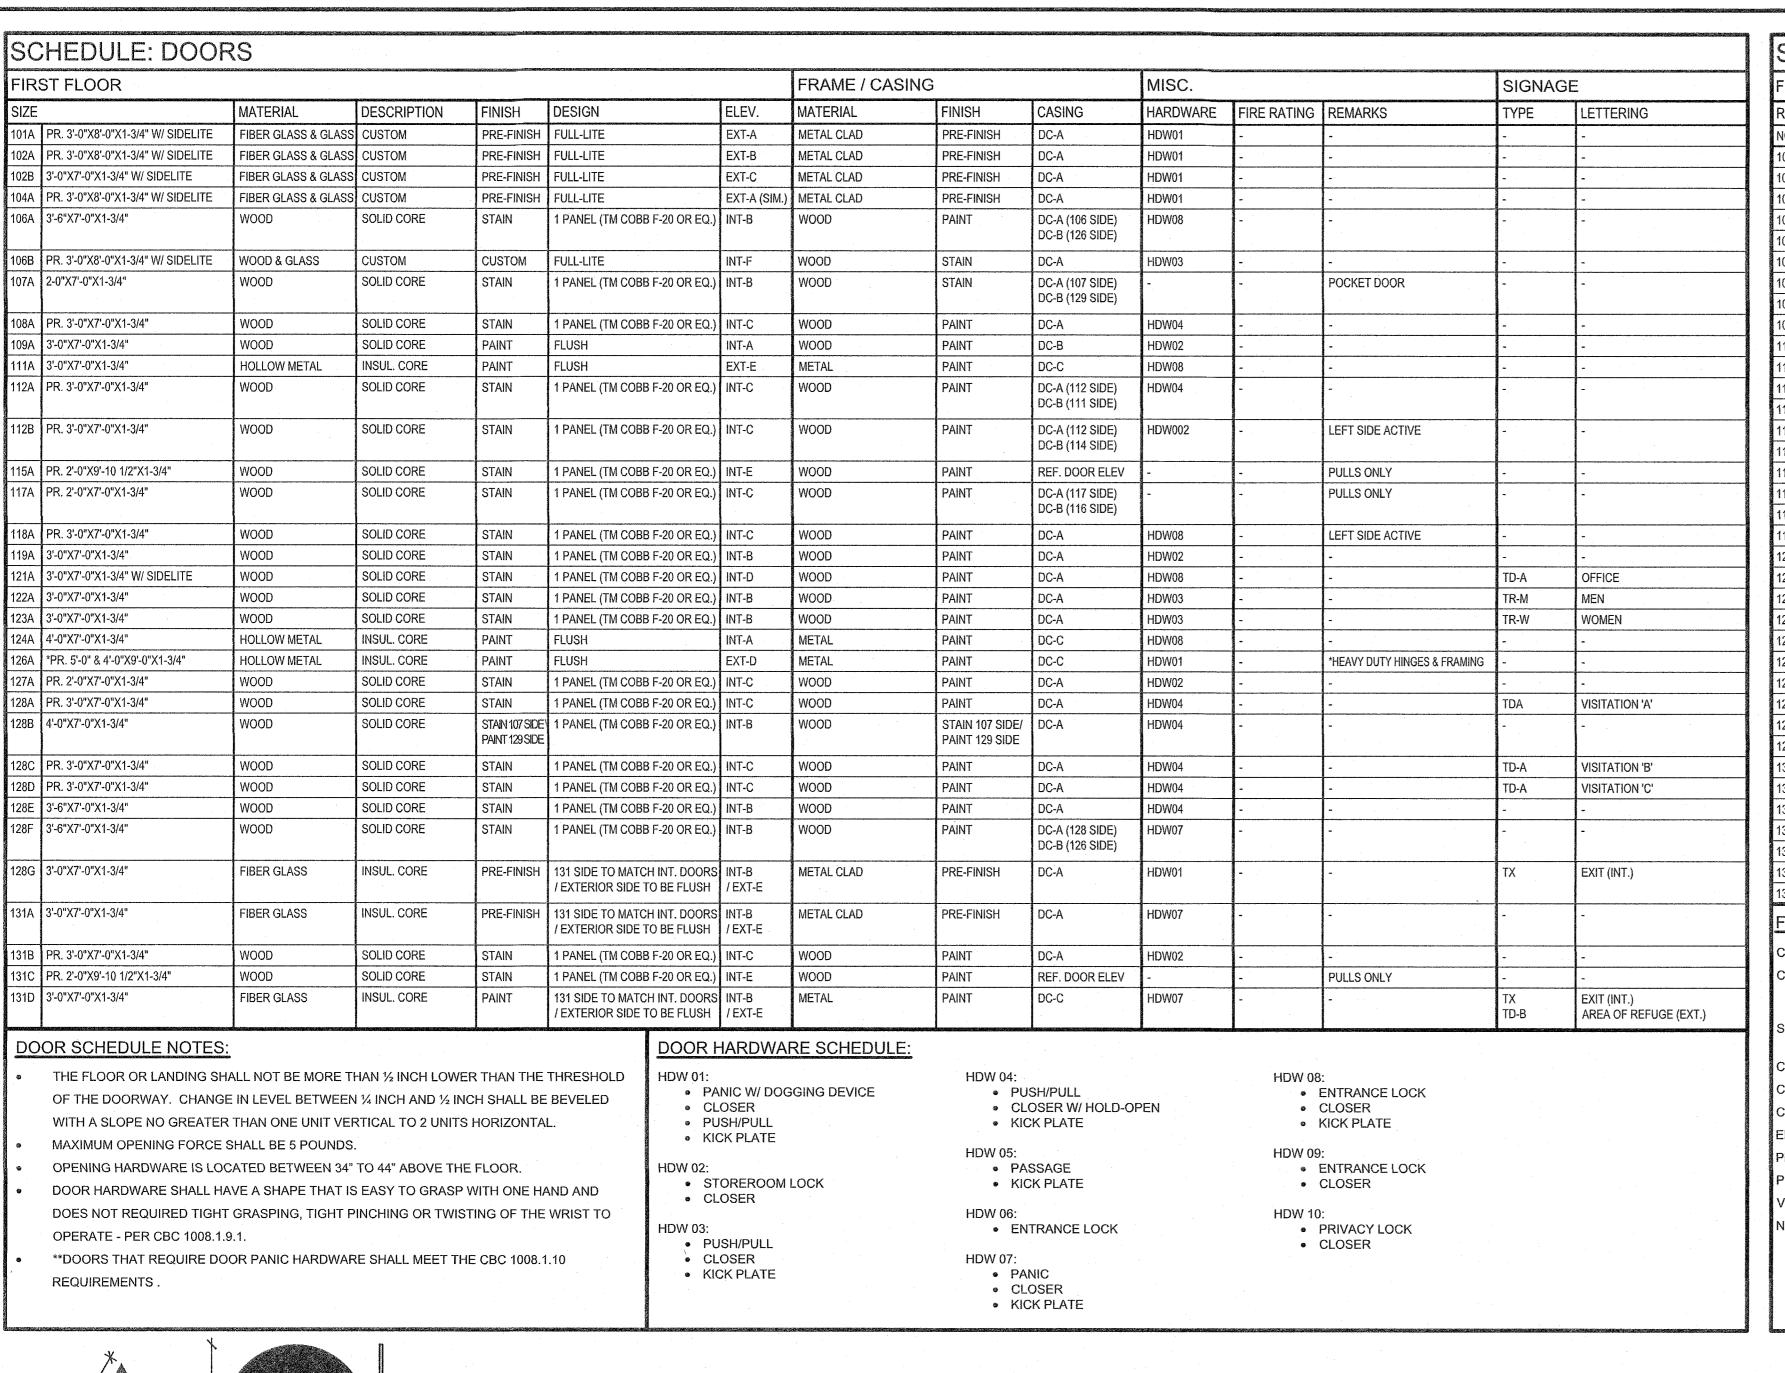

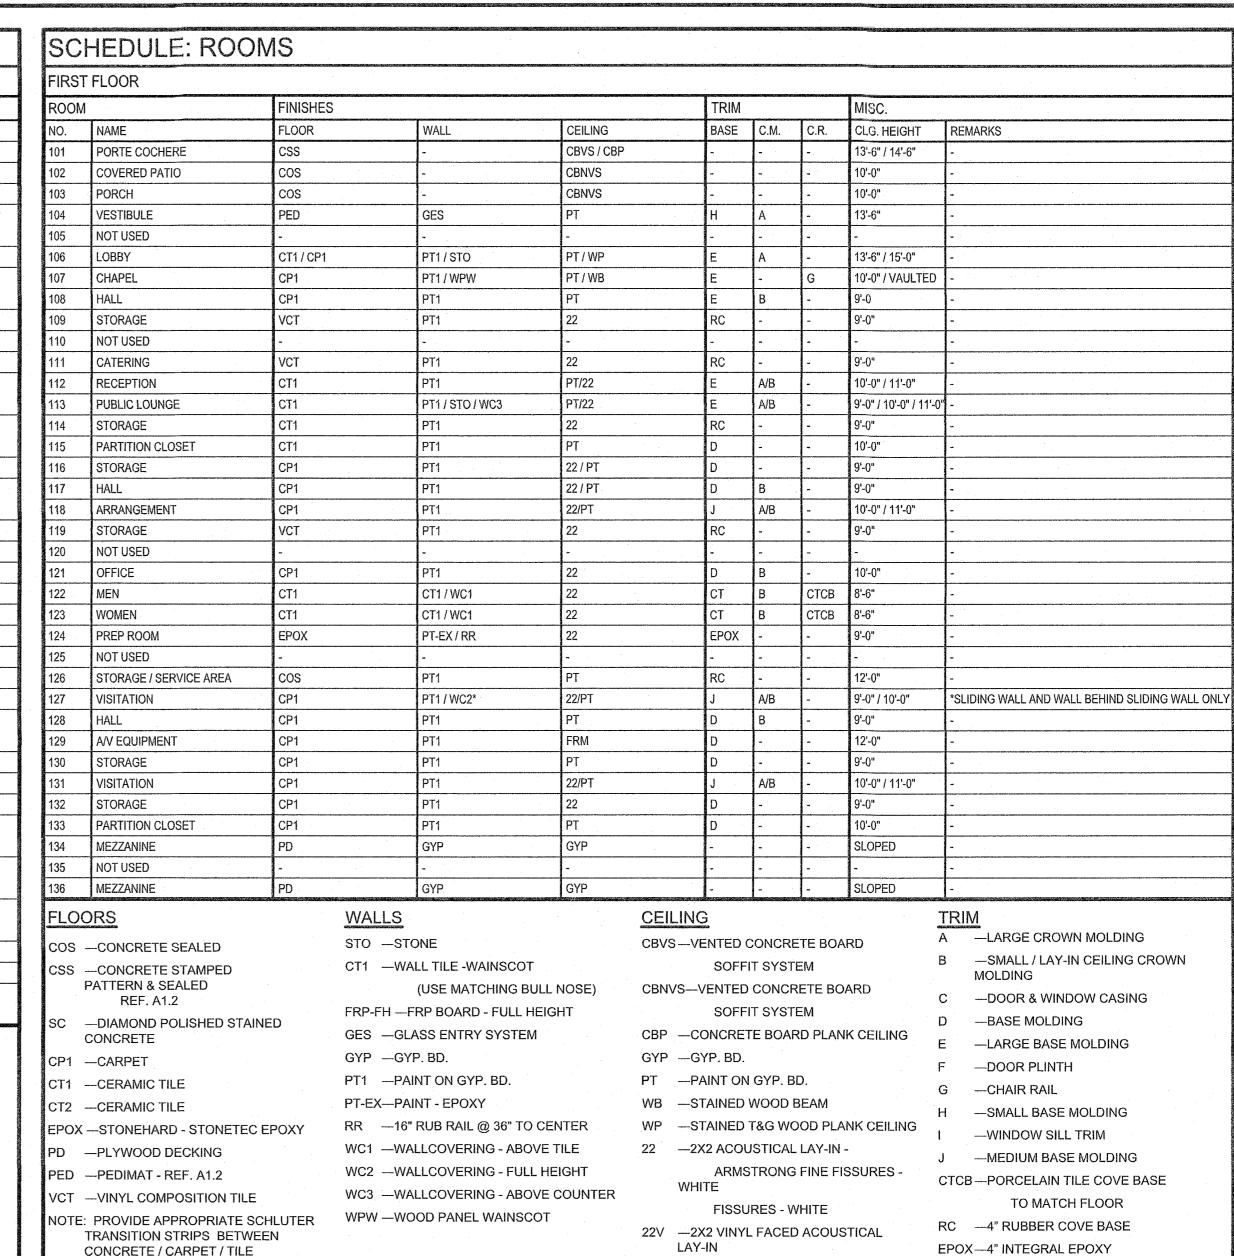

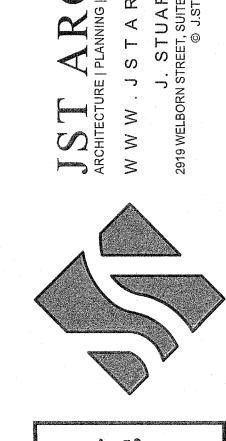


ISSUE DATE:

REVISION:


OCTOBER 6, 2017 PERMIT REVIEW



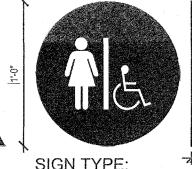


SIGN TYPE:

GEOMETRIC RESTOOM DOOR SIGNS

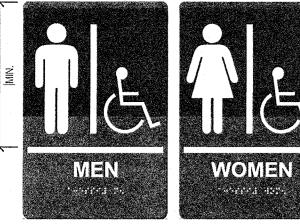

SIGN TYPE: 'TR-M'


'TR-W' TACTILE RESTROOM SIGNS

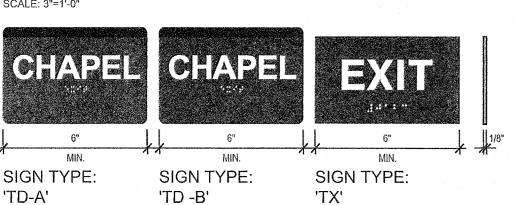

TACTILE DIRECTIONAL SIGNS

'XT' (EXTERIOR GRADE)

TACTILE EXIT SIGNS

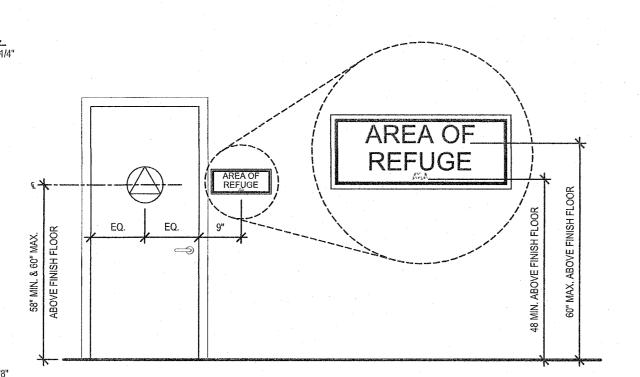



RESTROOM & TACTILE SIGN MOUNTING REQUIREMENTS




SIGNAGE NOTES


ALL ACCESSIBLE/TACTILE SIGNAGE TO COMPLY WITH 2009 ICC A117.1 ACCESSIBLE & USABLE BUILDINGS & FACILITIES BACKGROUND COLOR: STANDARD BLACK OR COLOR AS COPY COLOR: STANDARD WHITE OR COLOR AS CHOSEN BY ARCHITECT MARKER

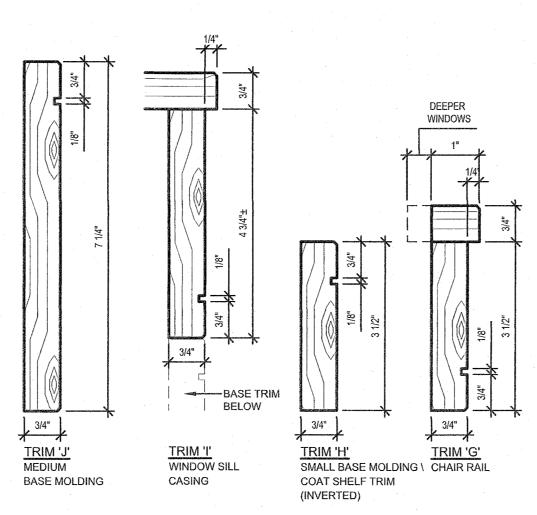

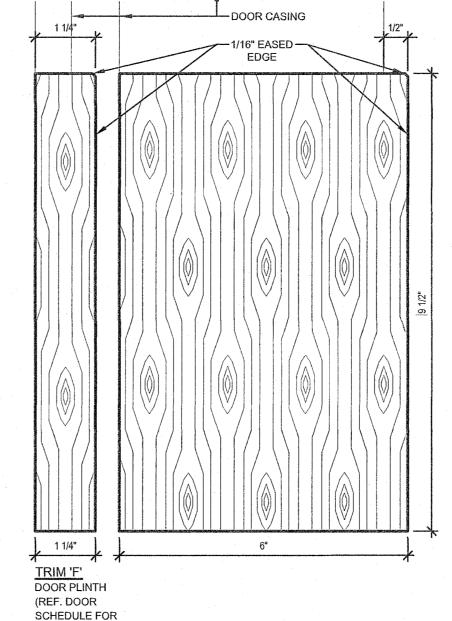

LOCATIONS)

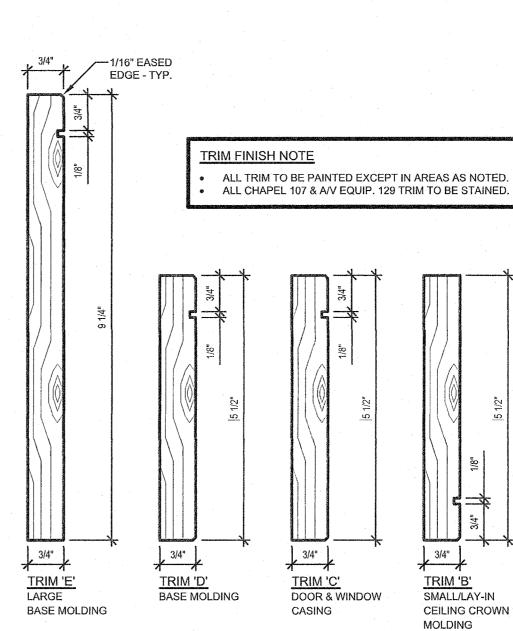


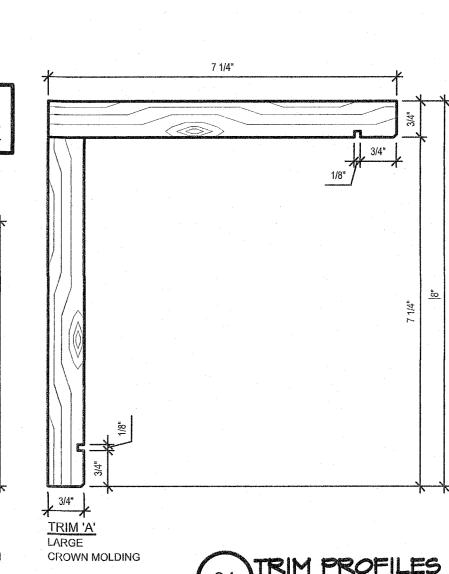



BASE - STONTEC


SHEET NO.


A2.0

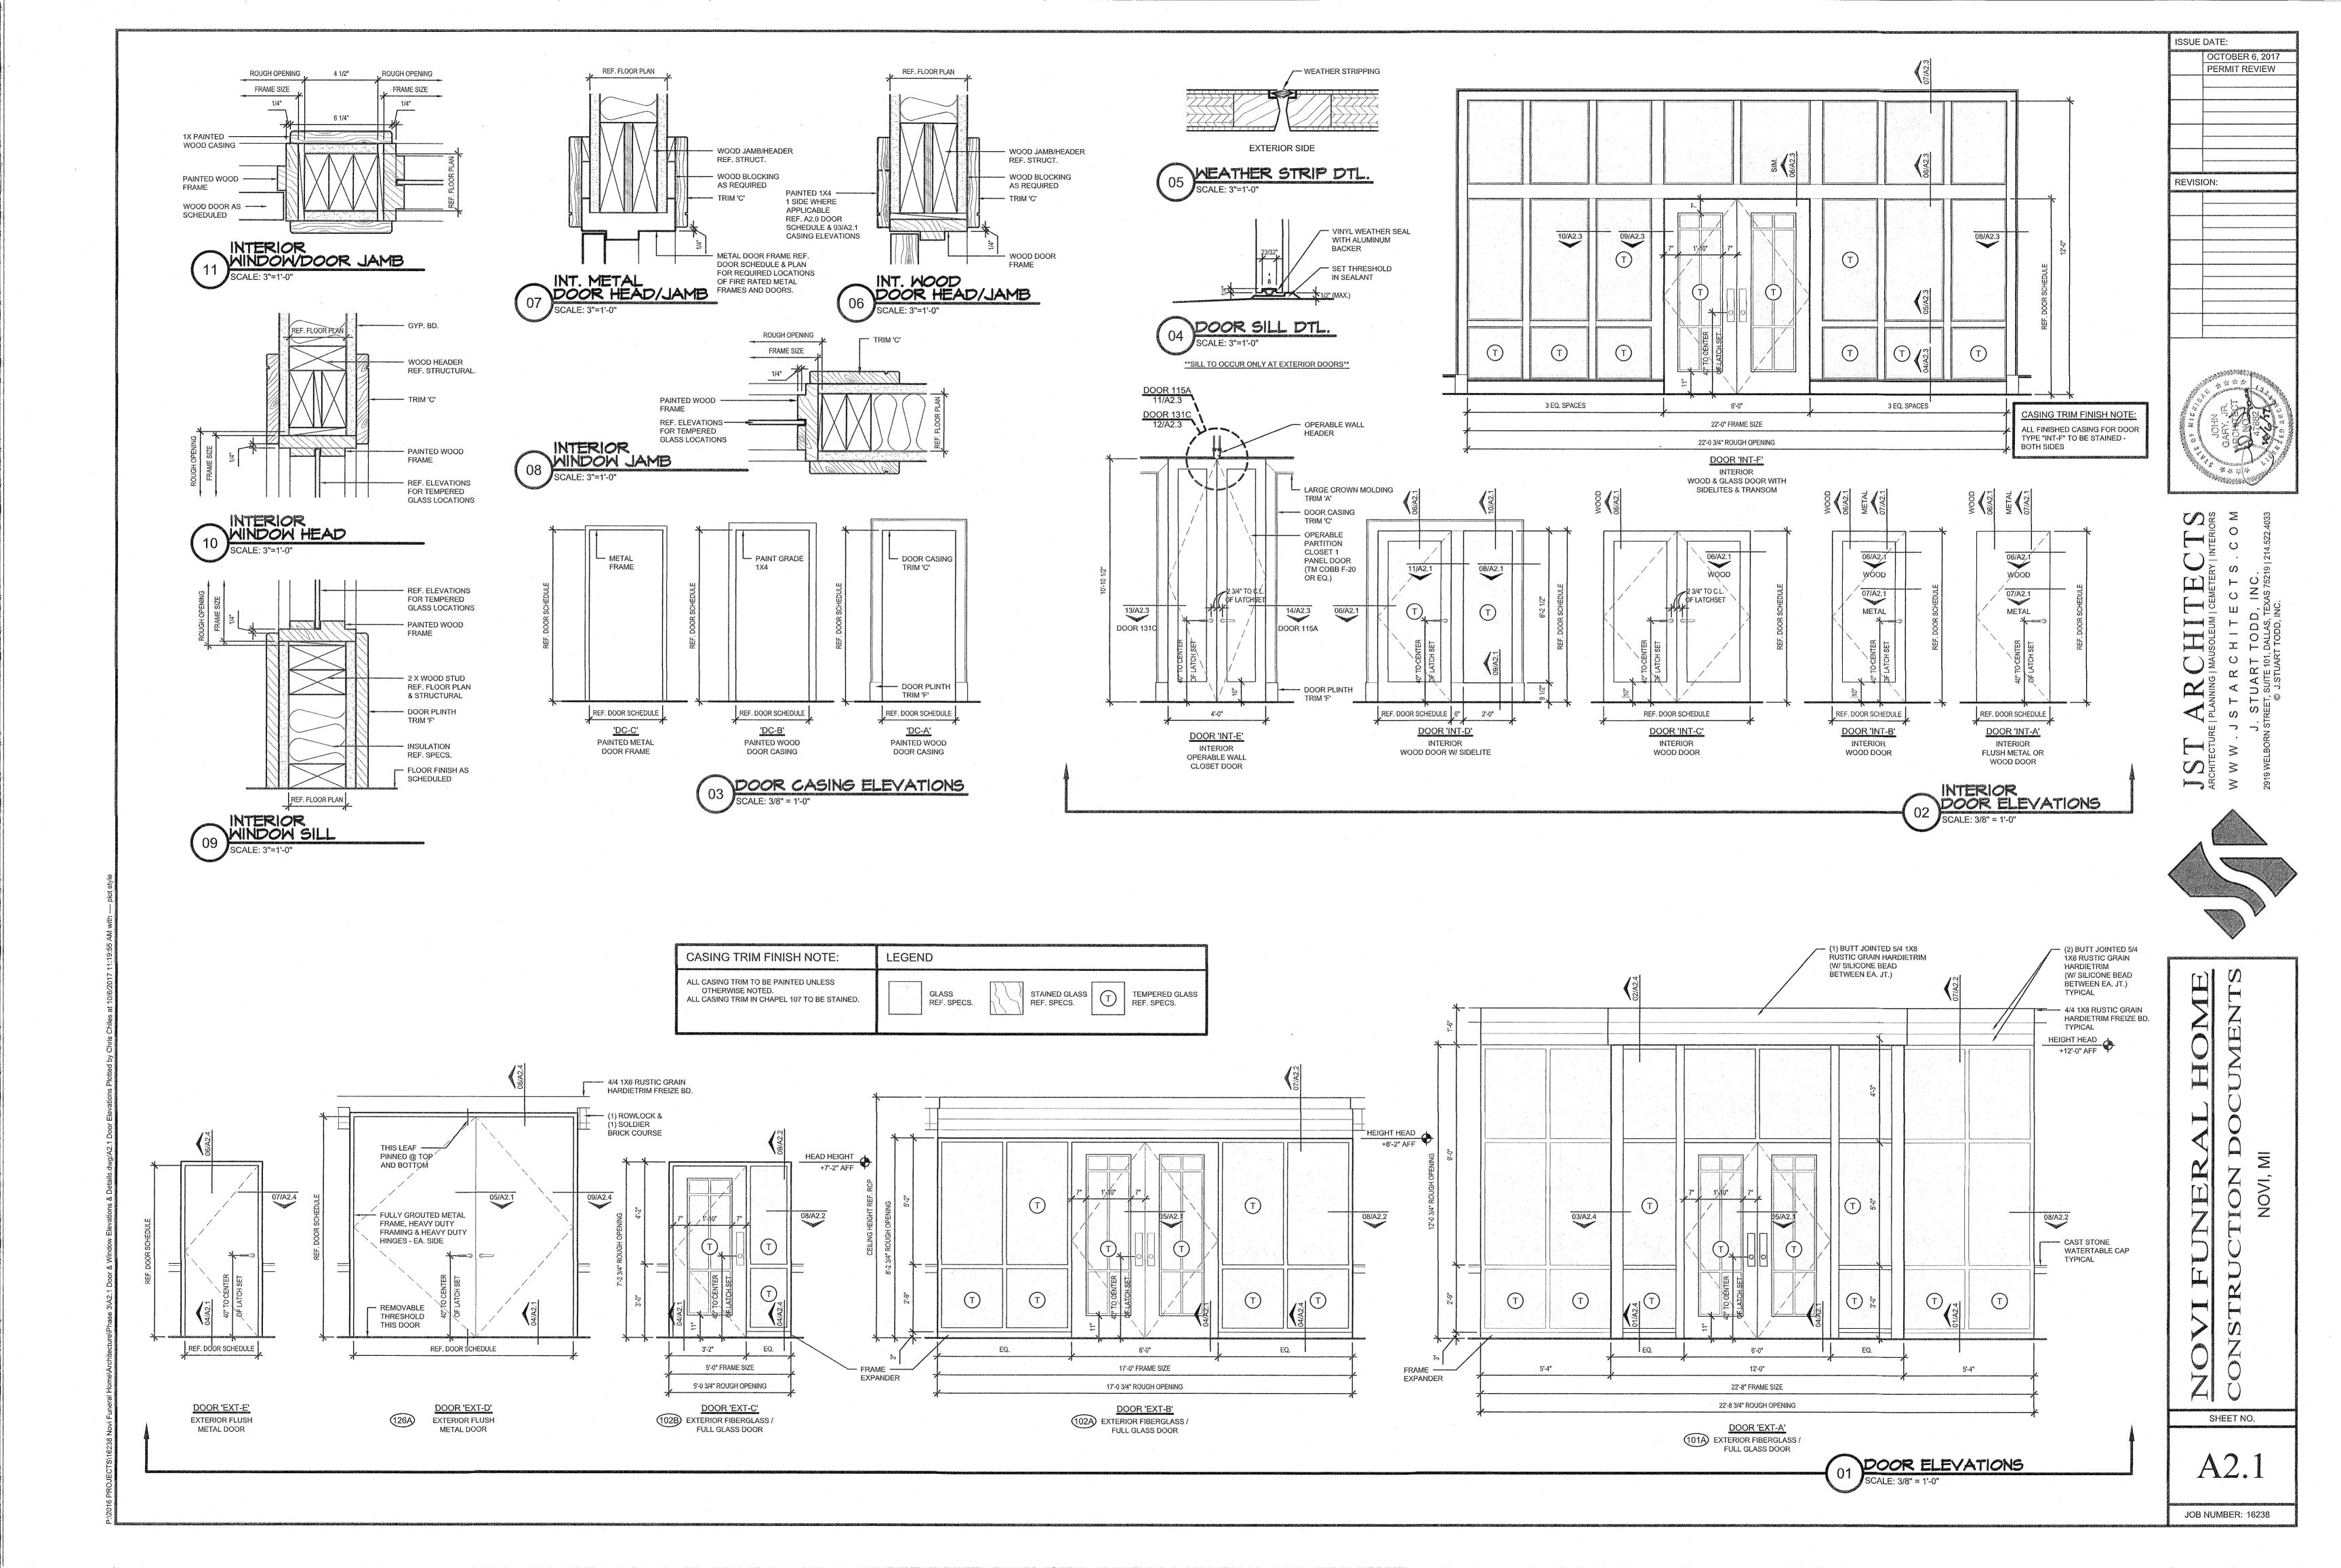


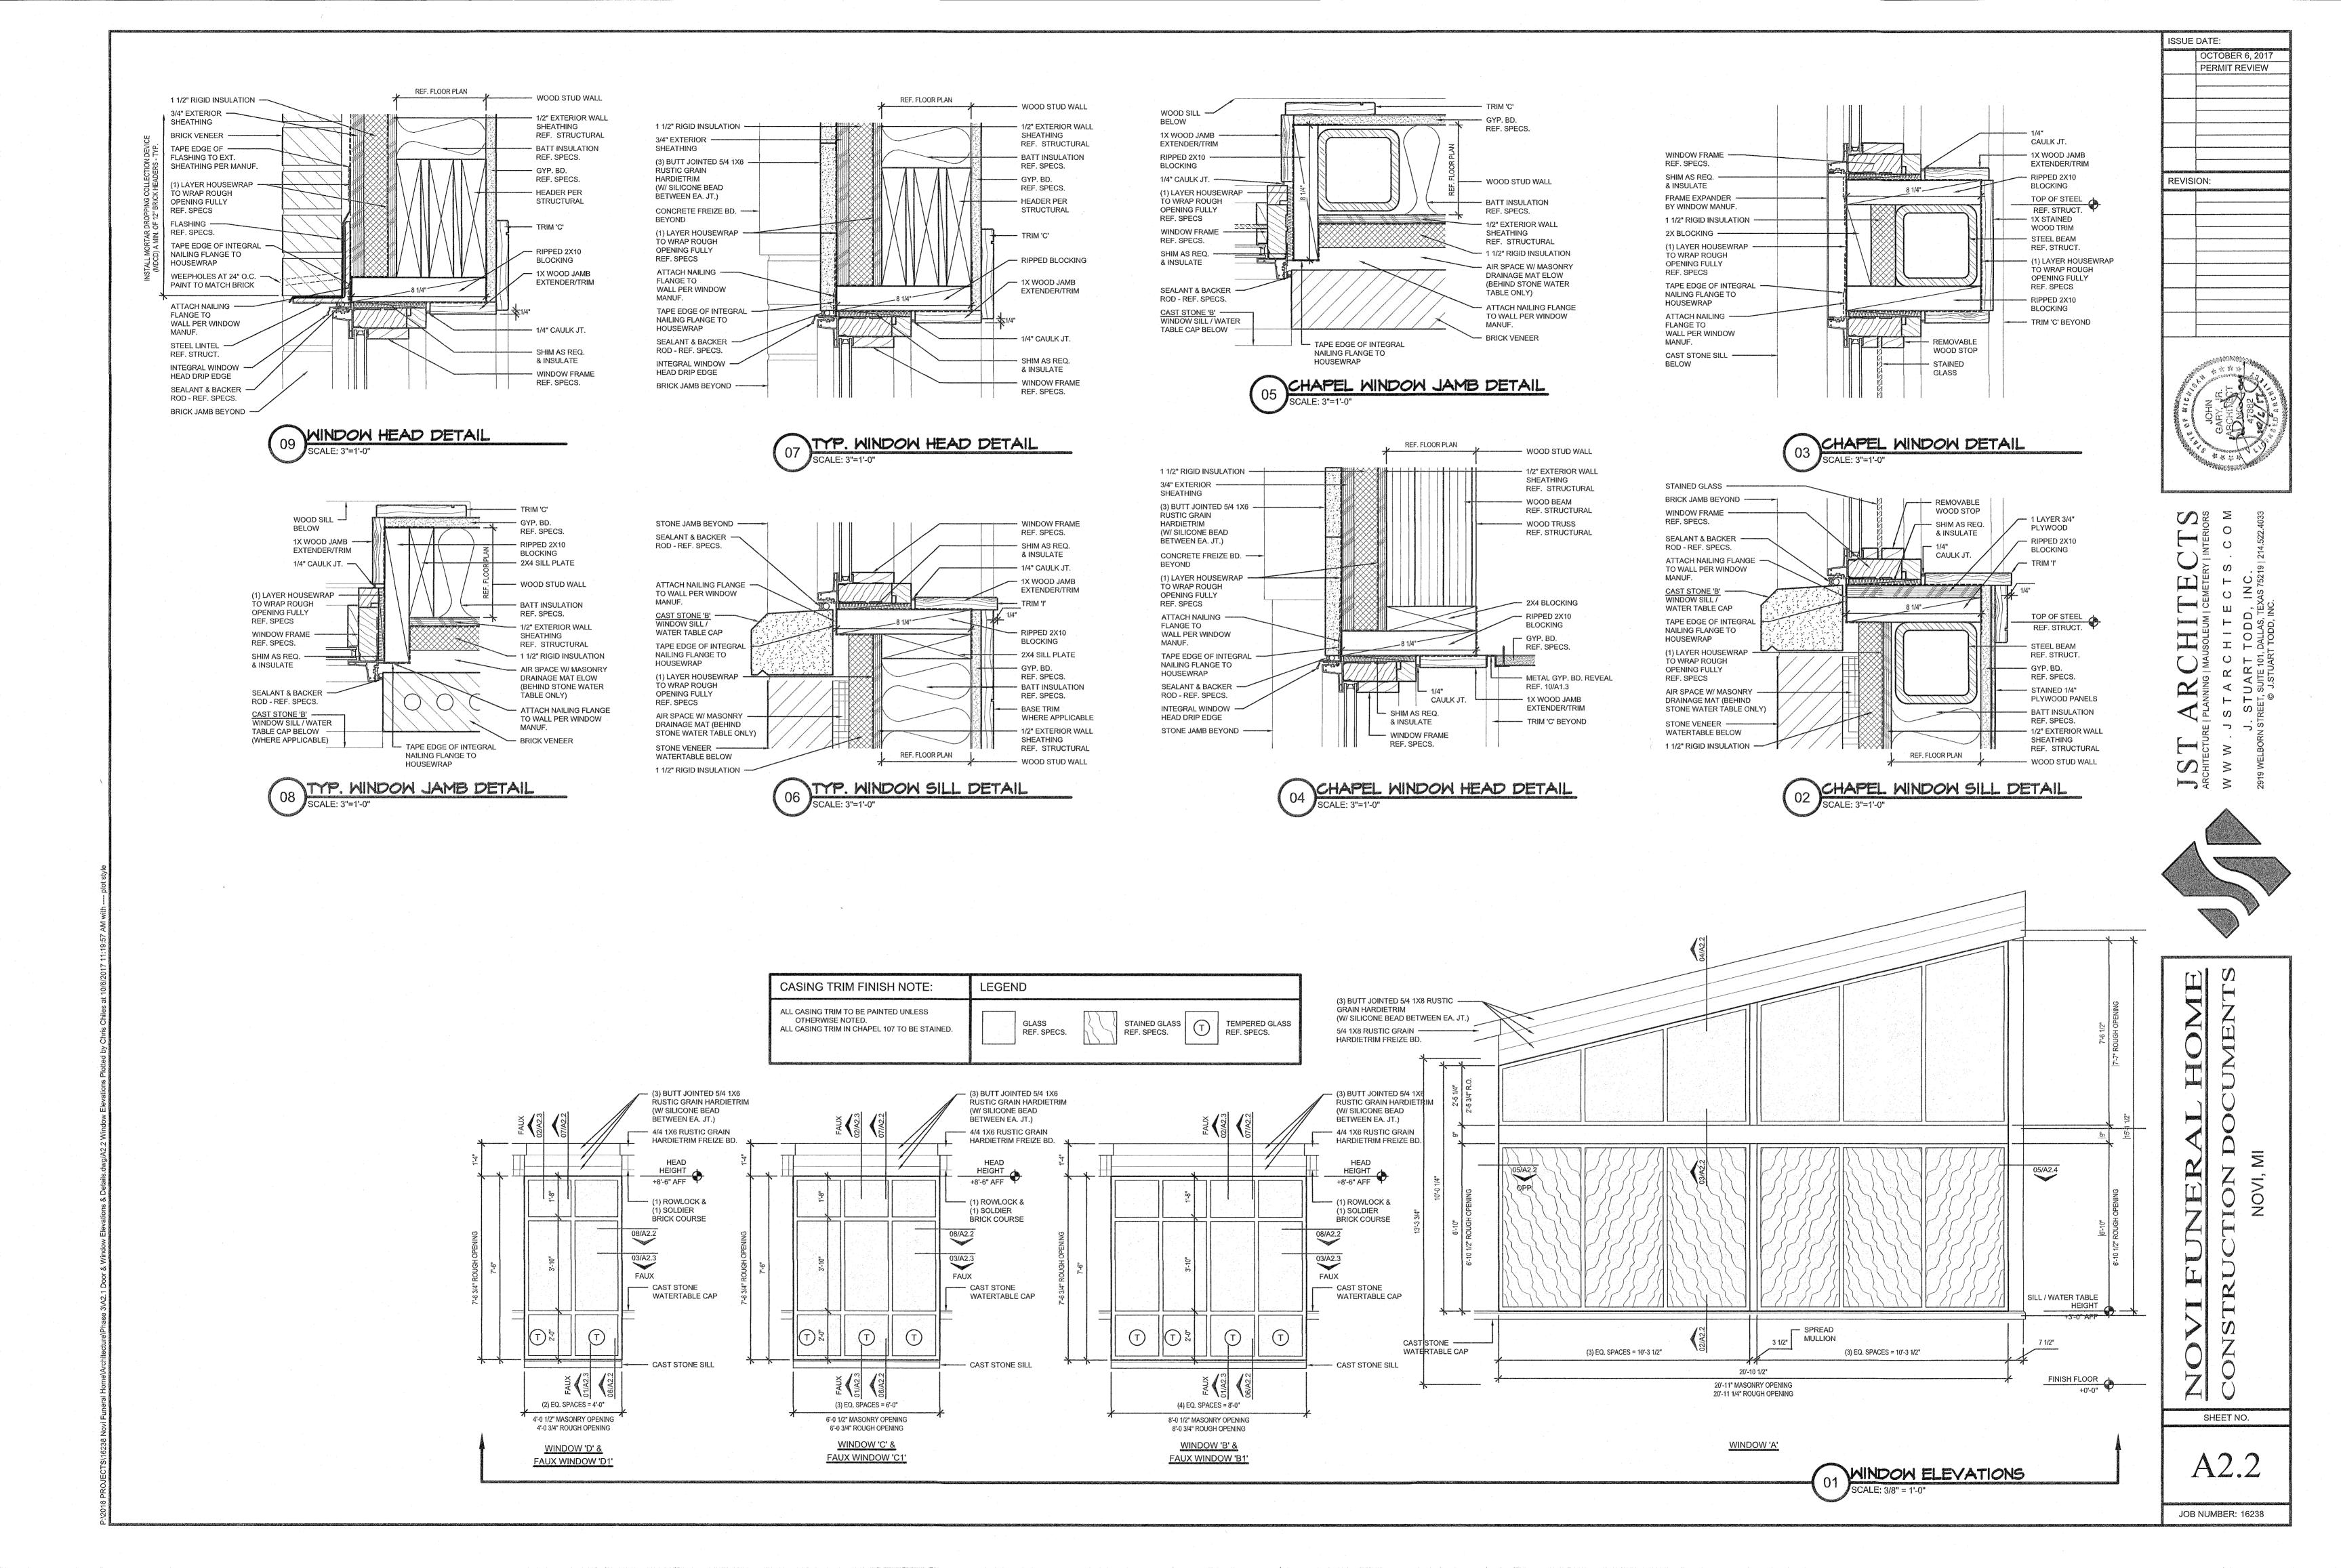


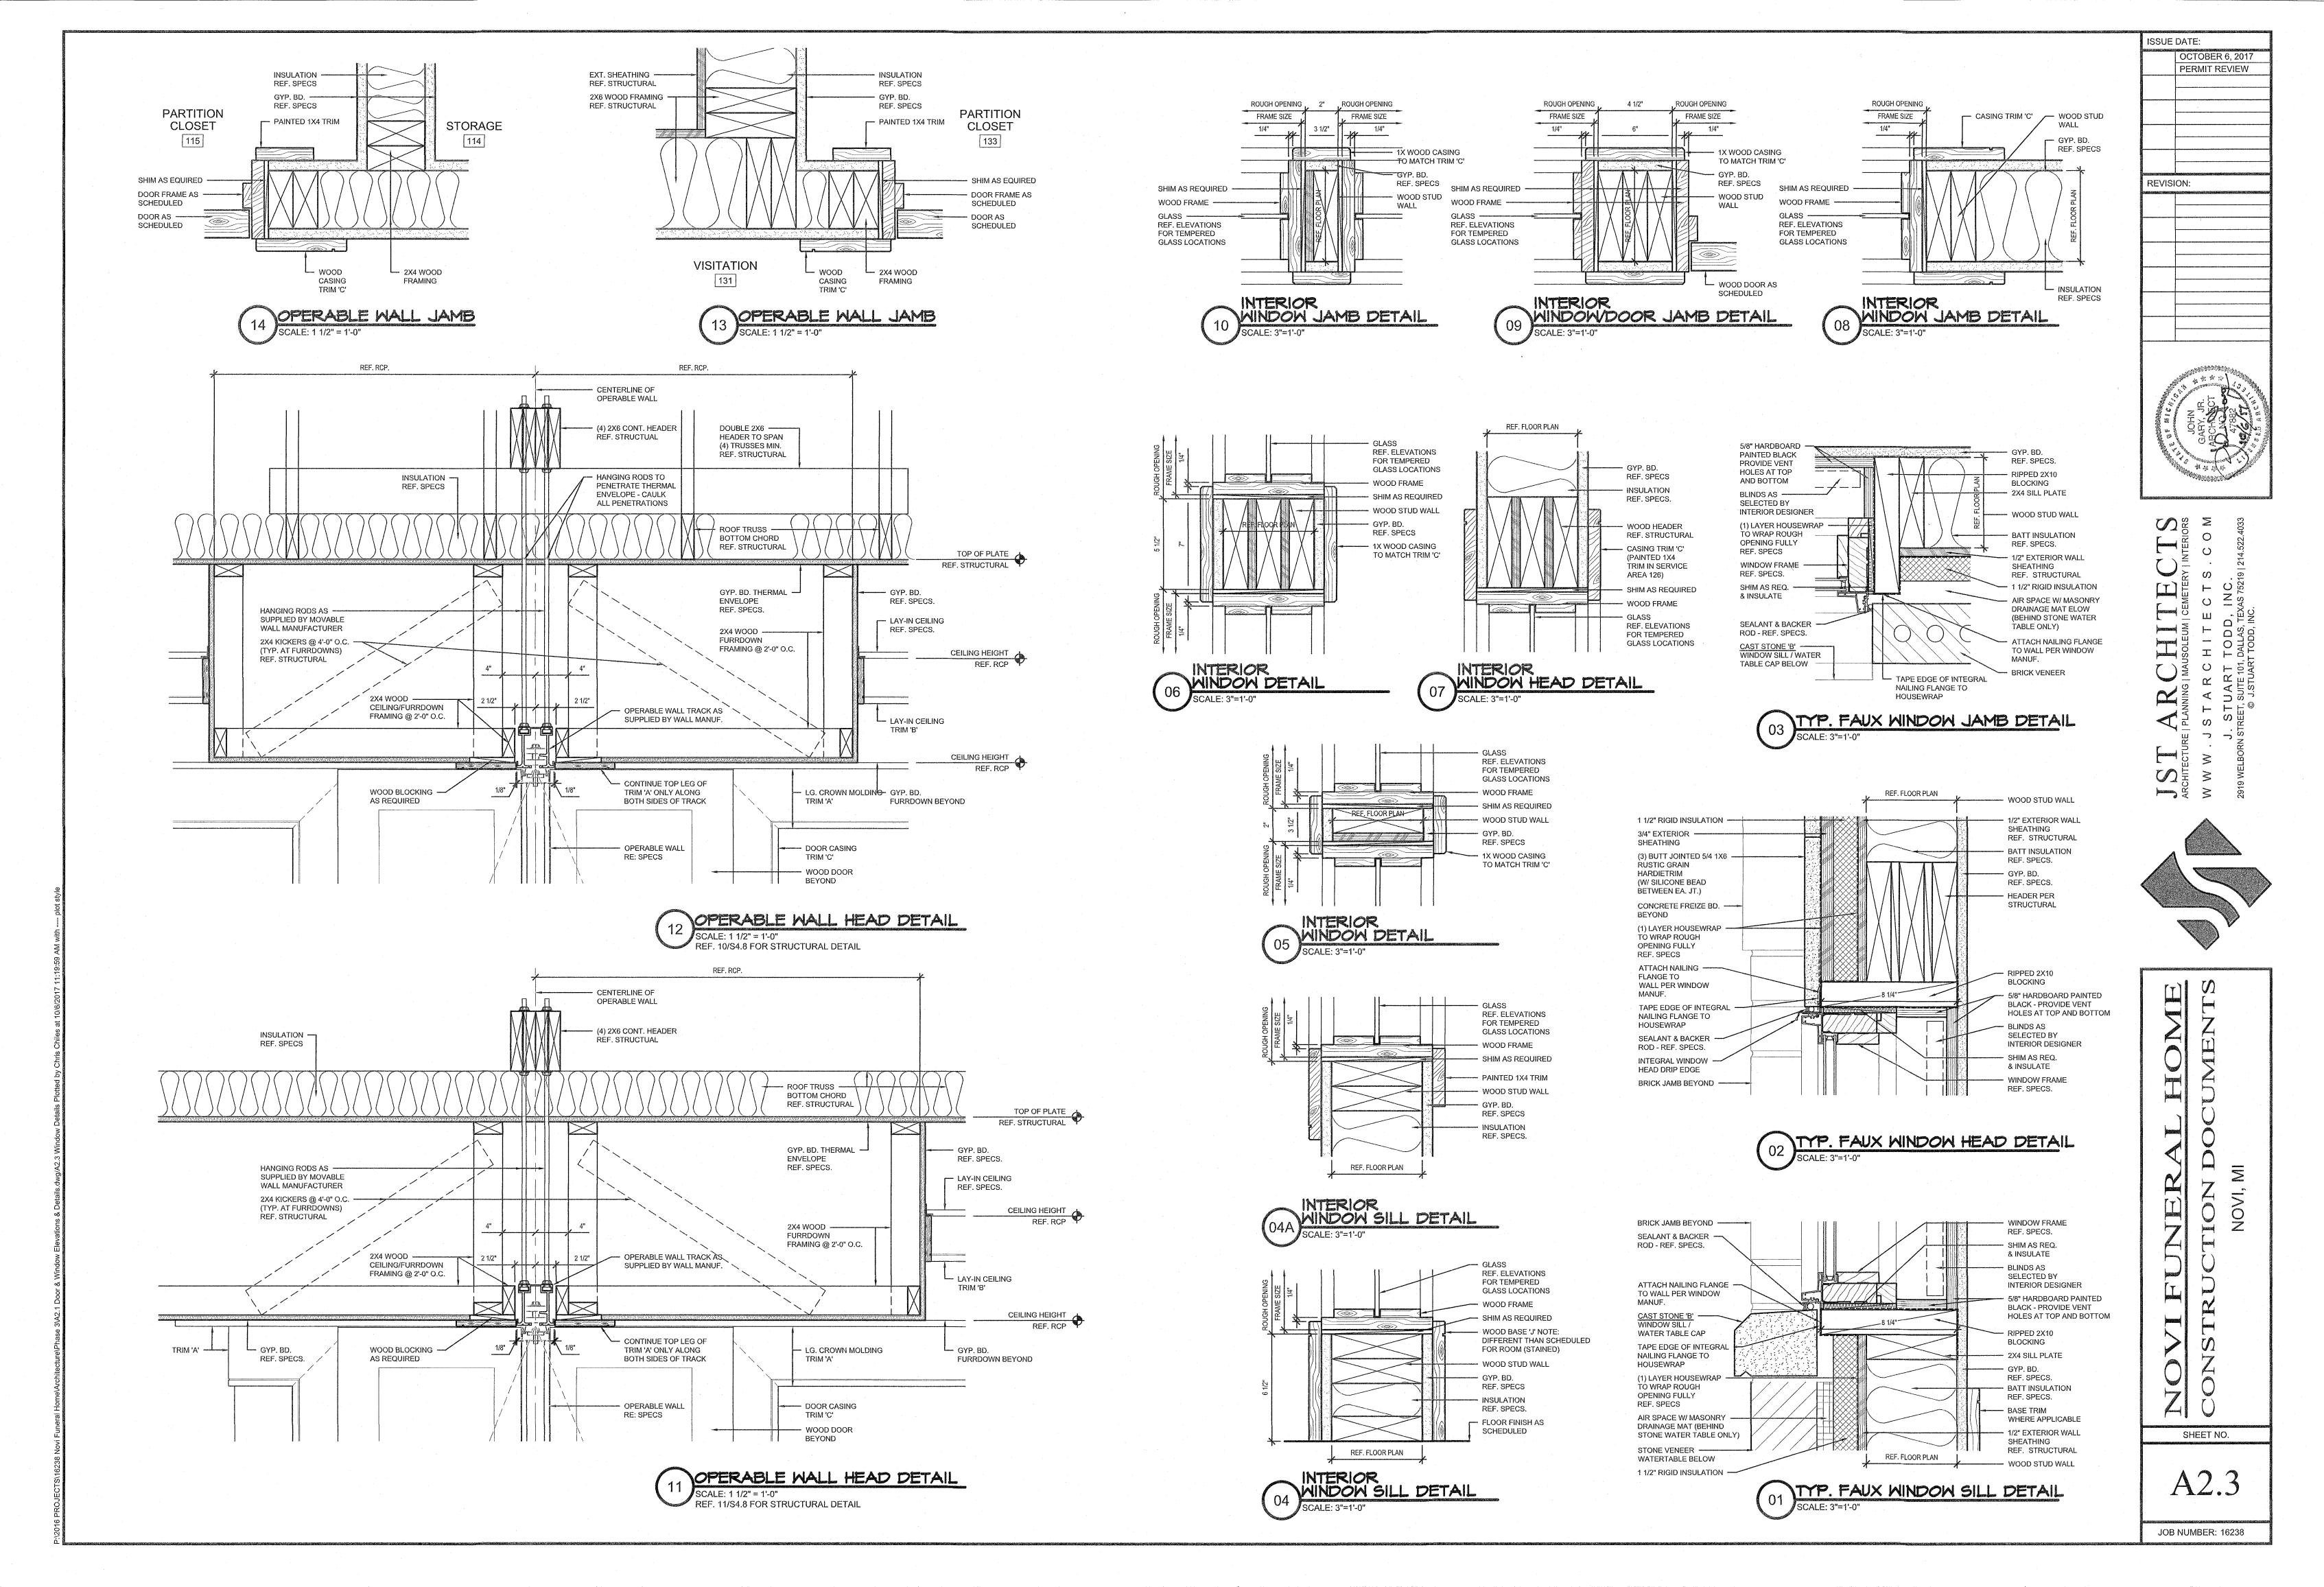


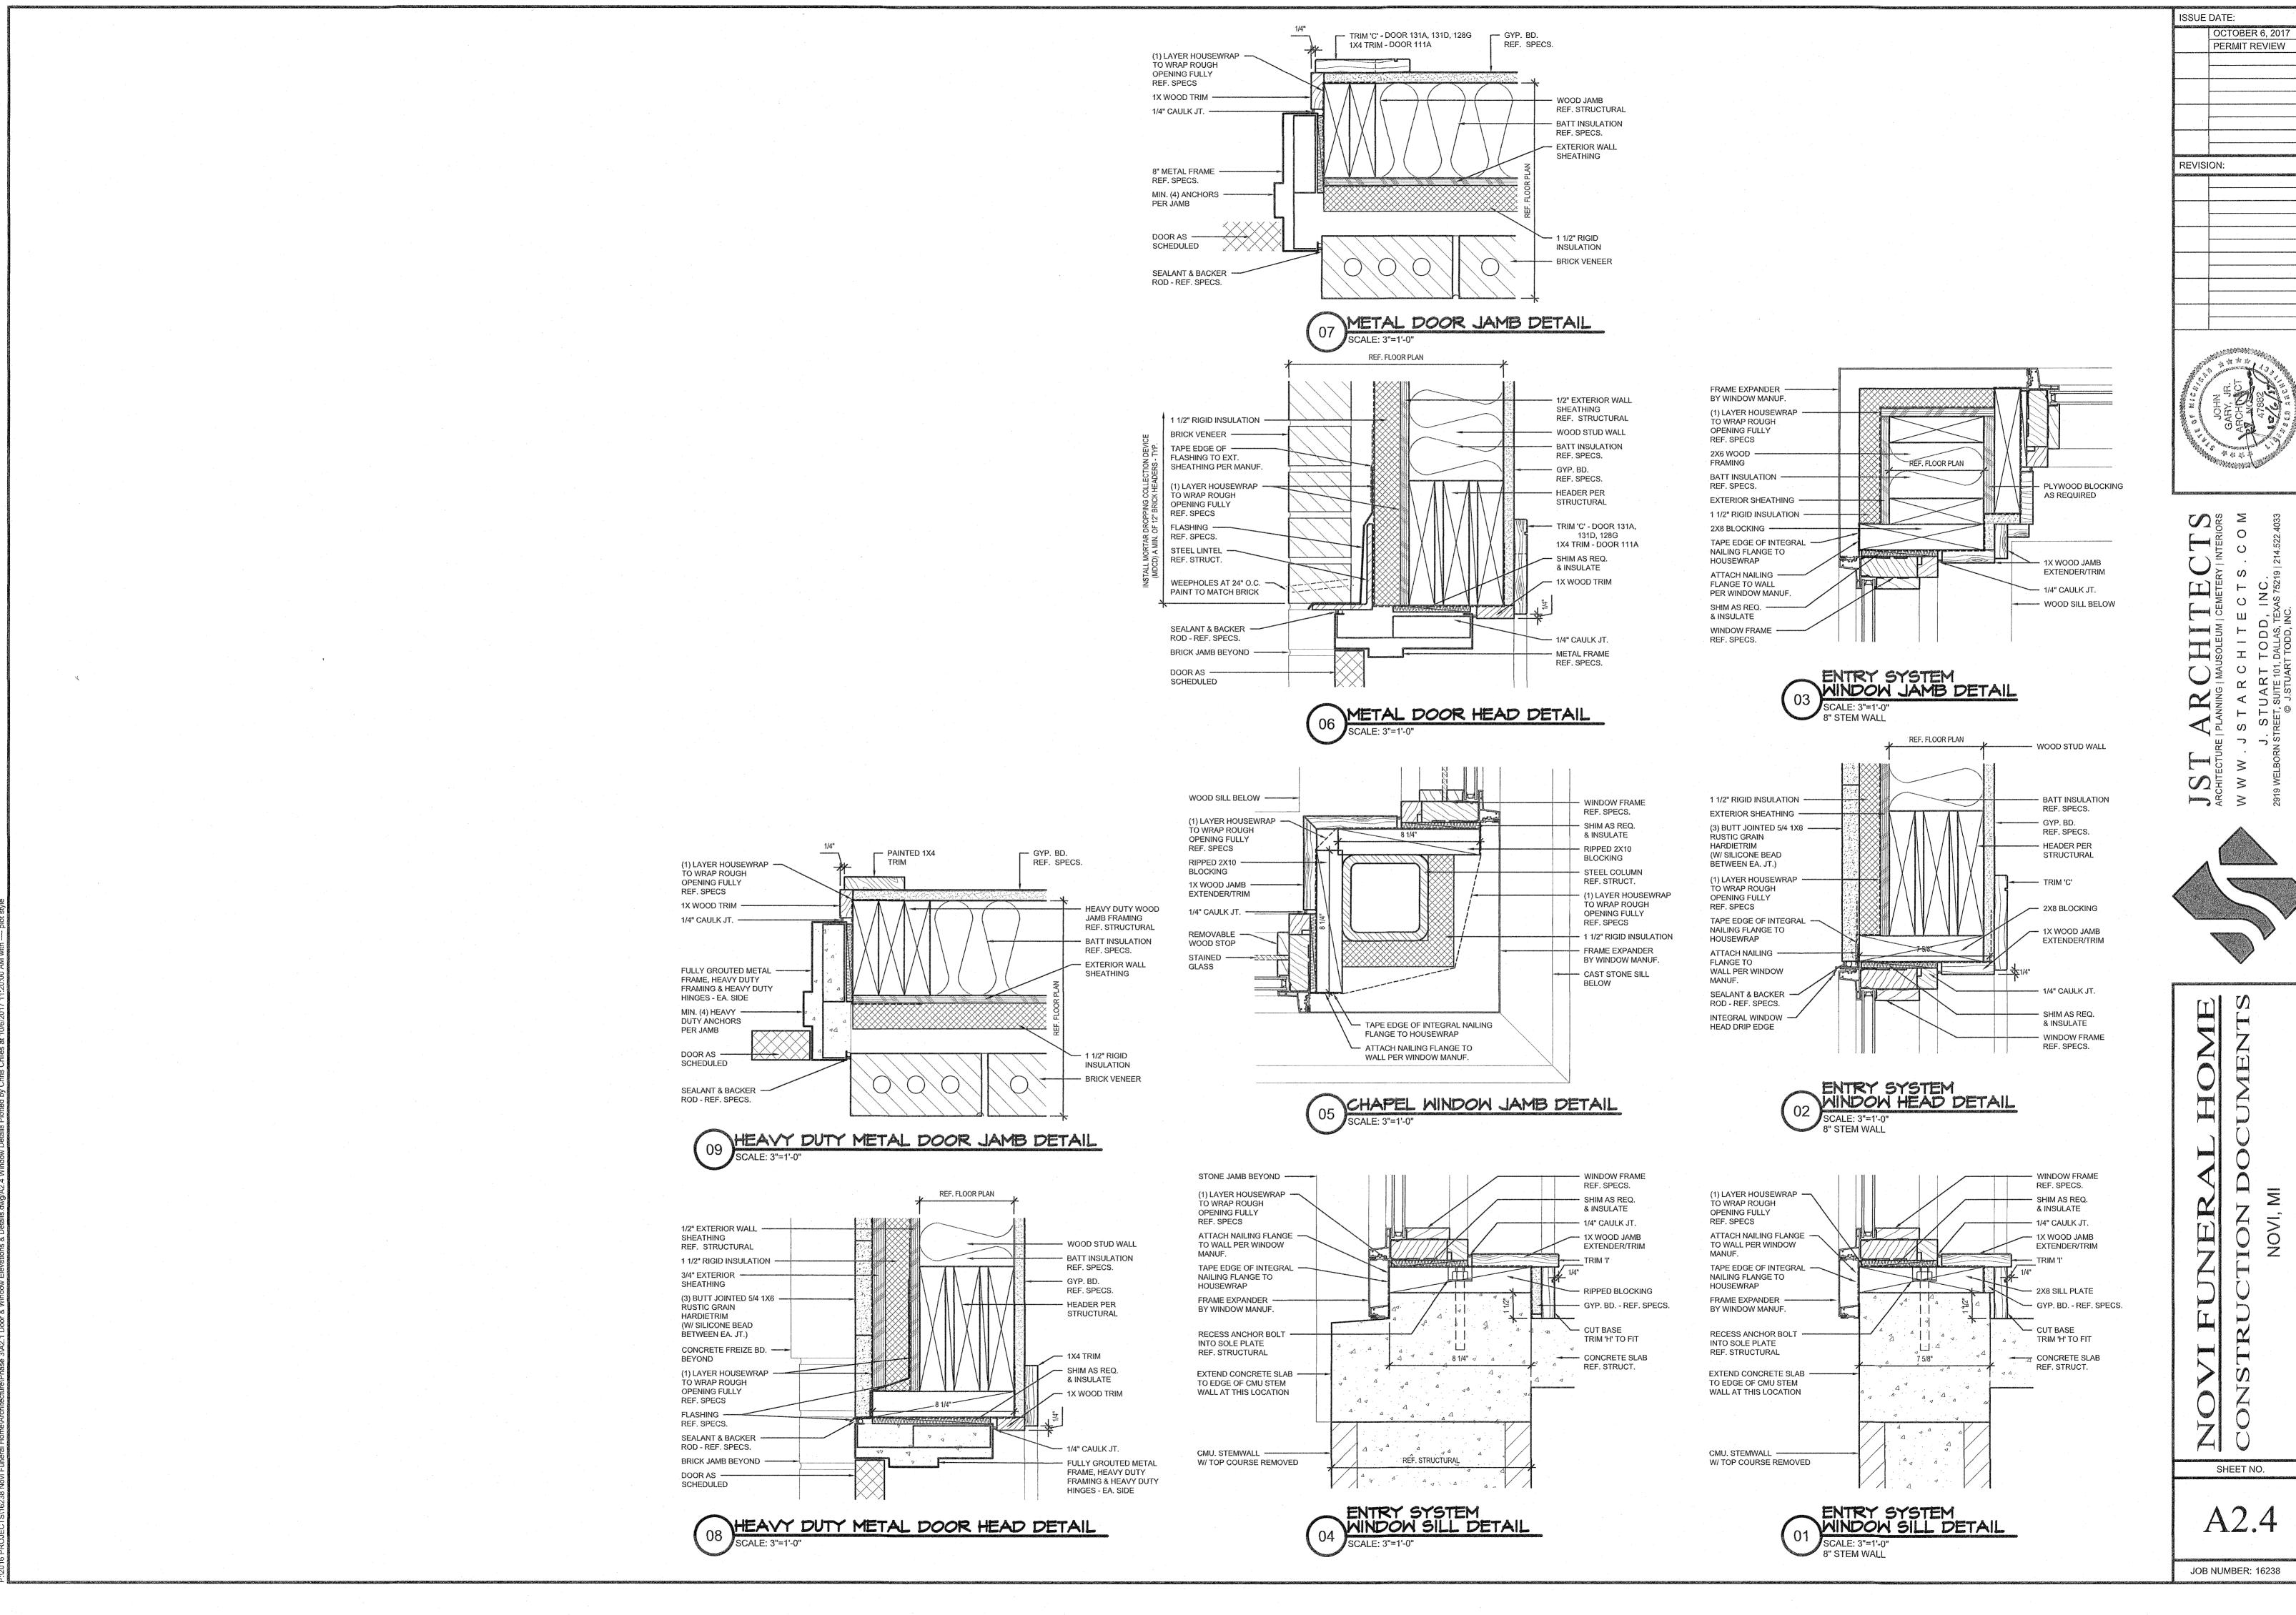


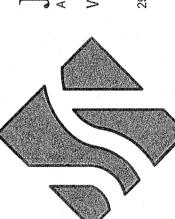


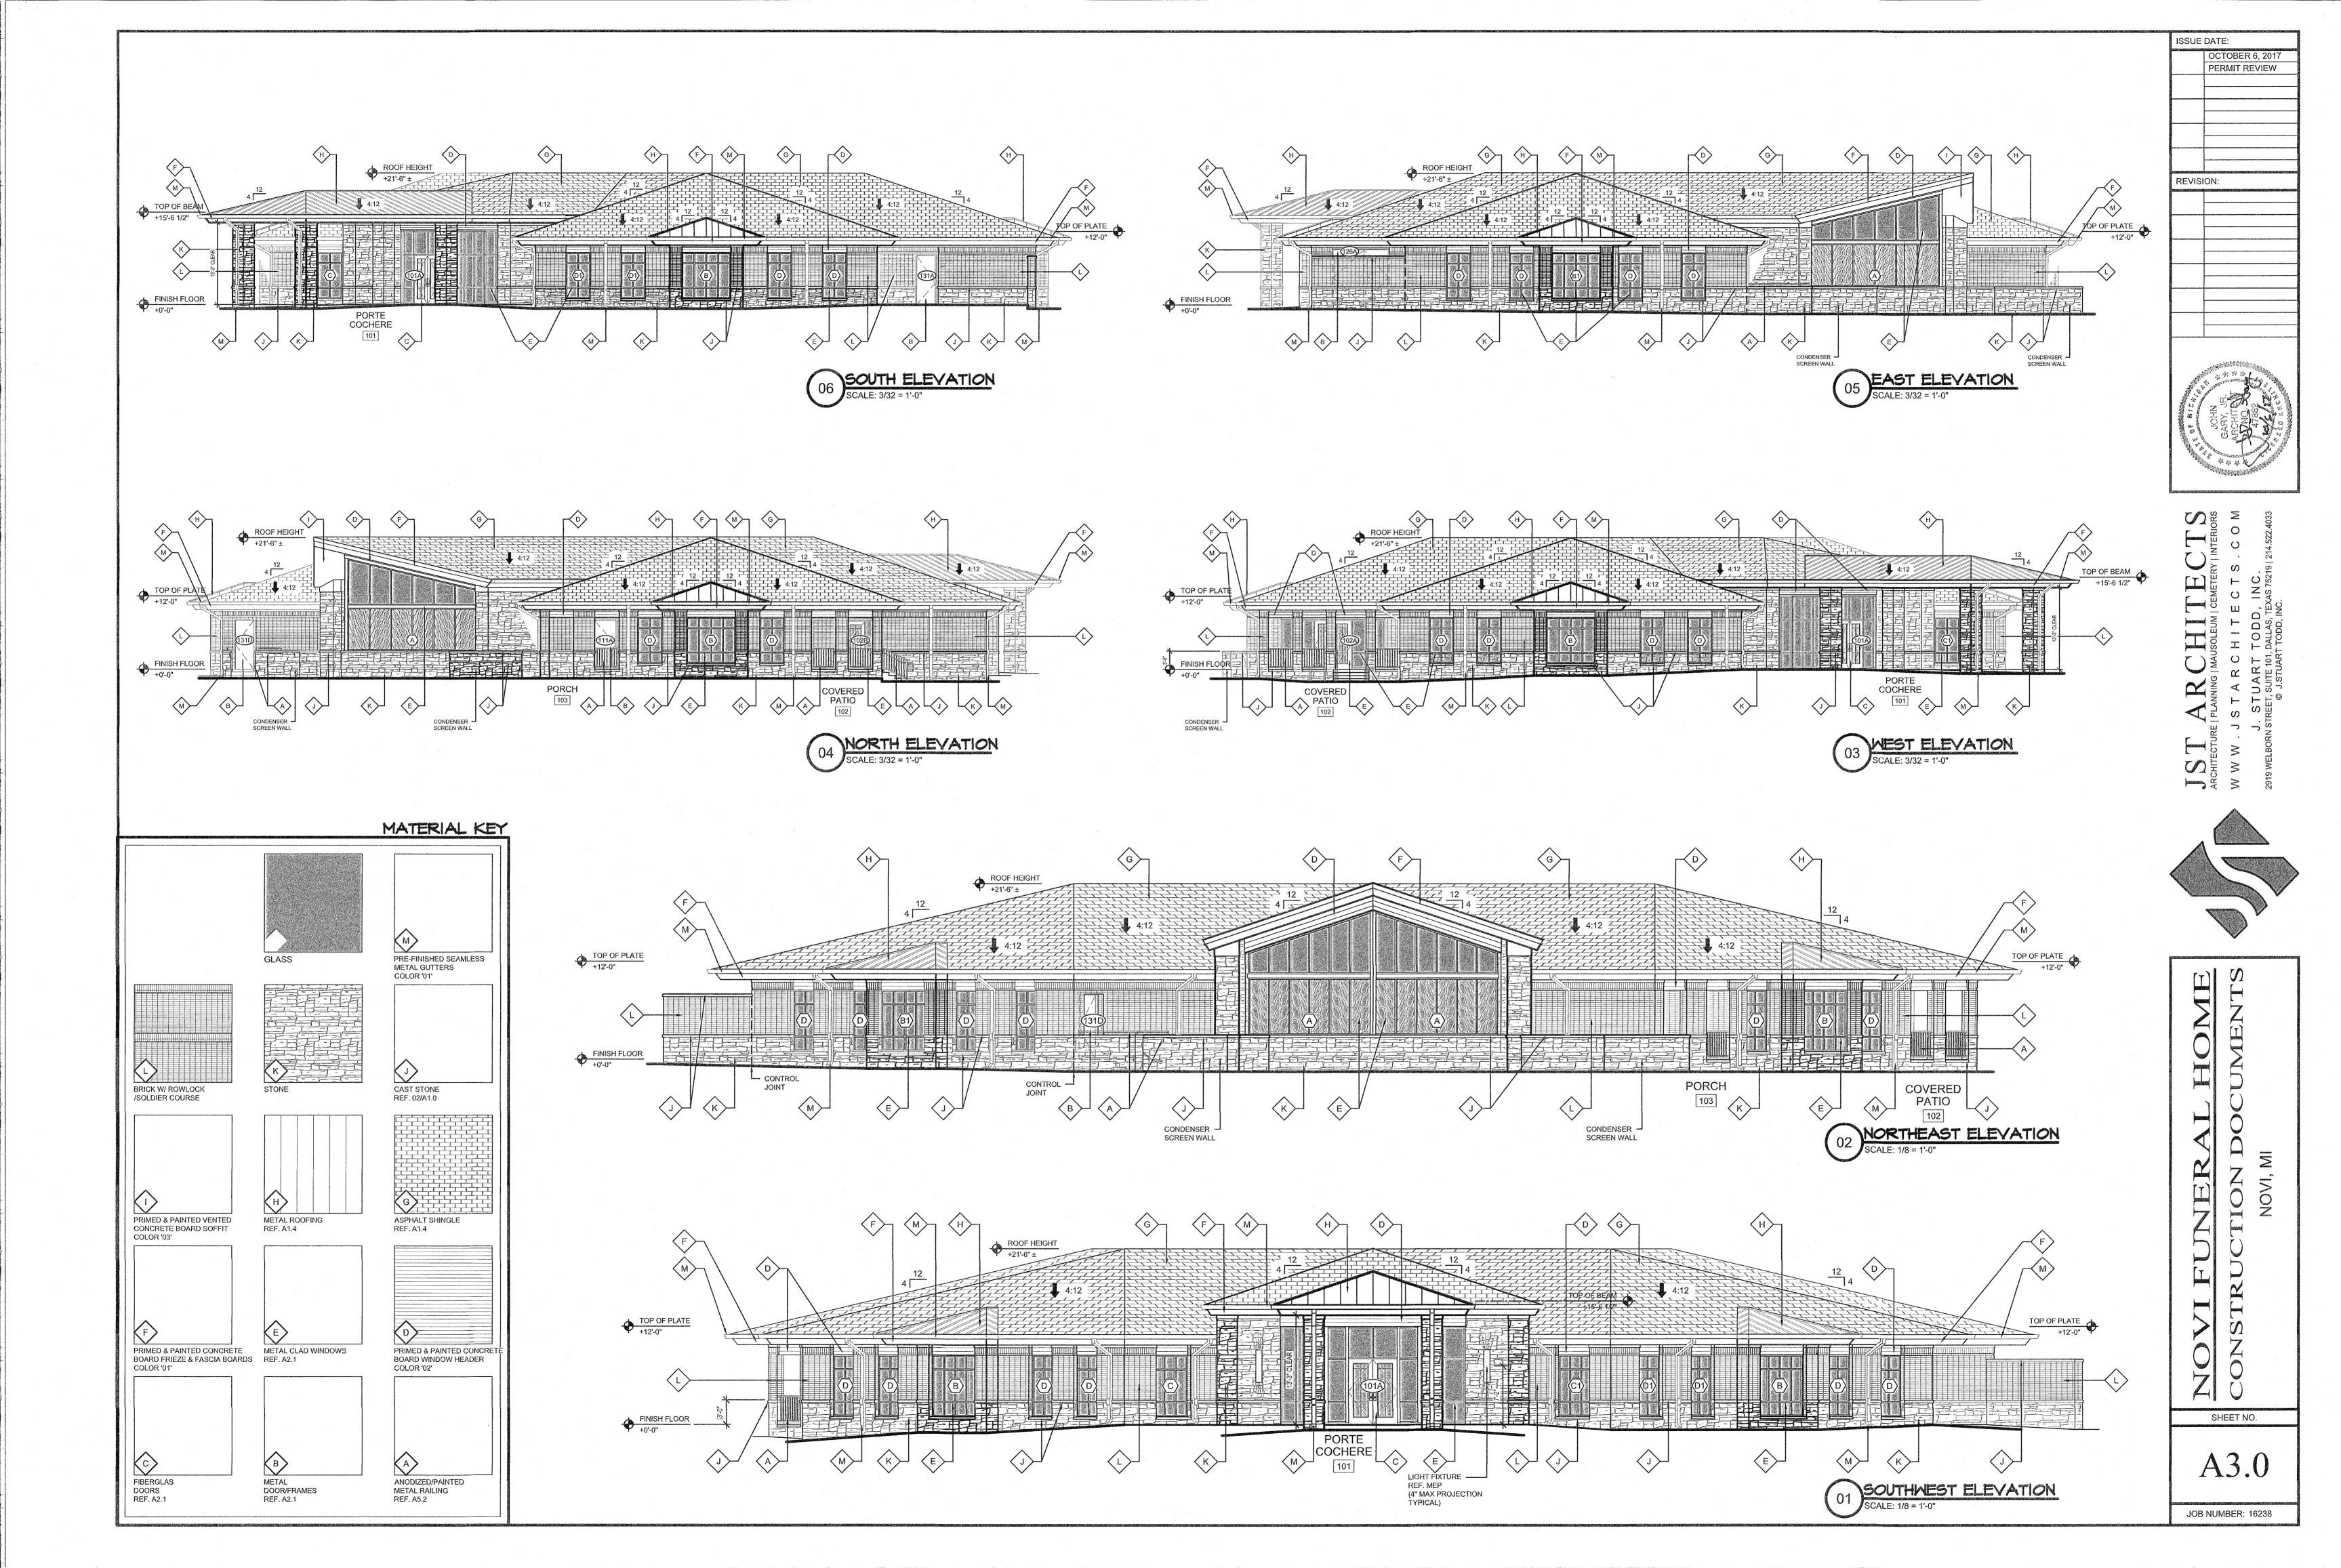


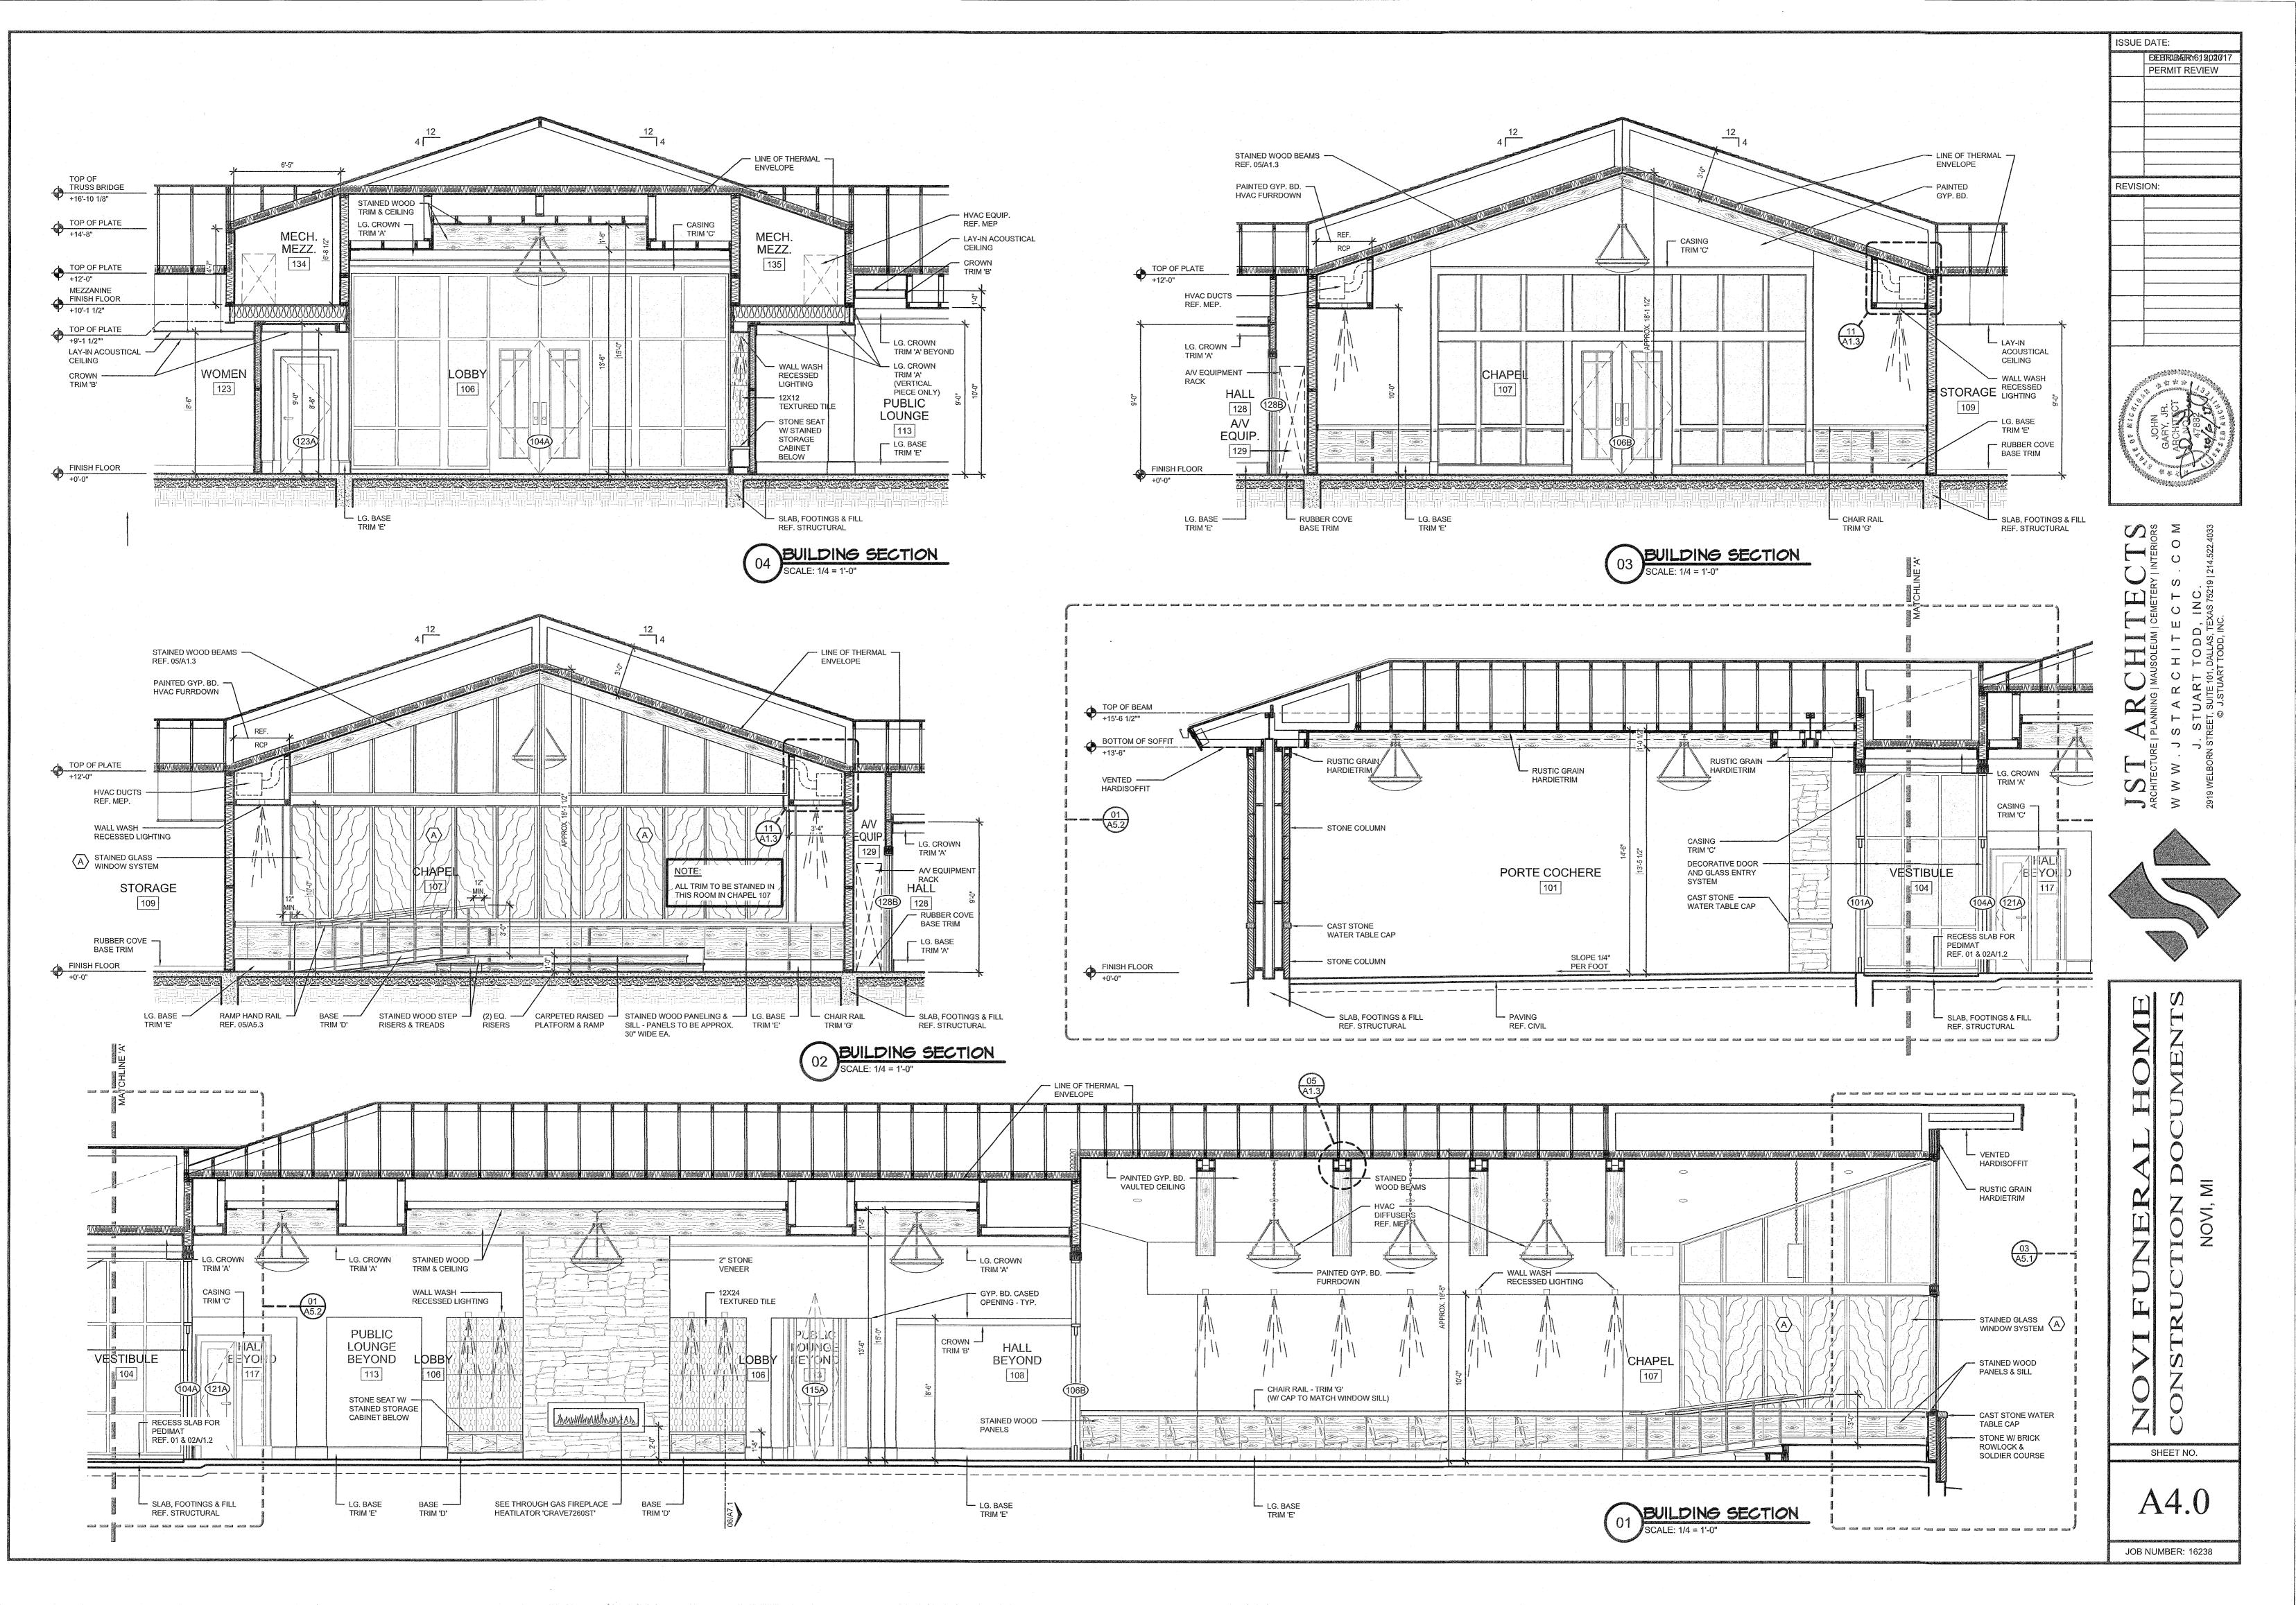


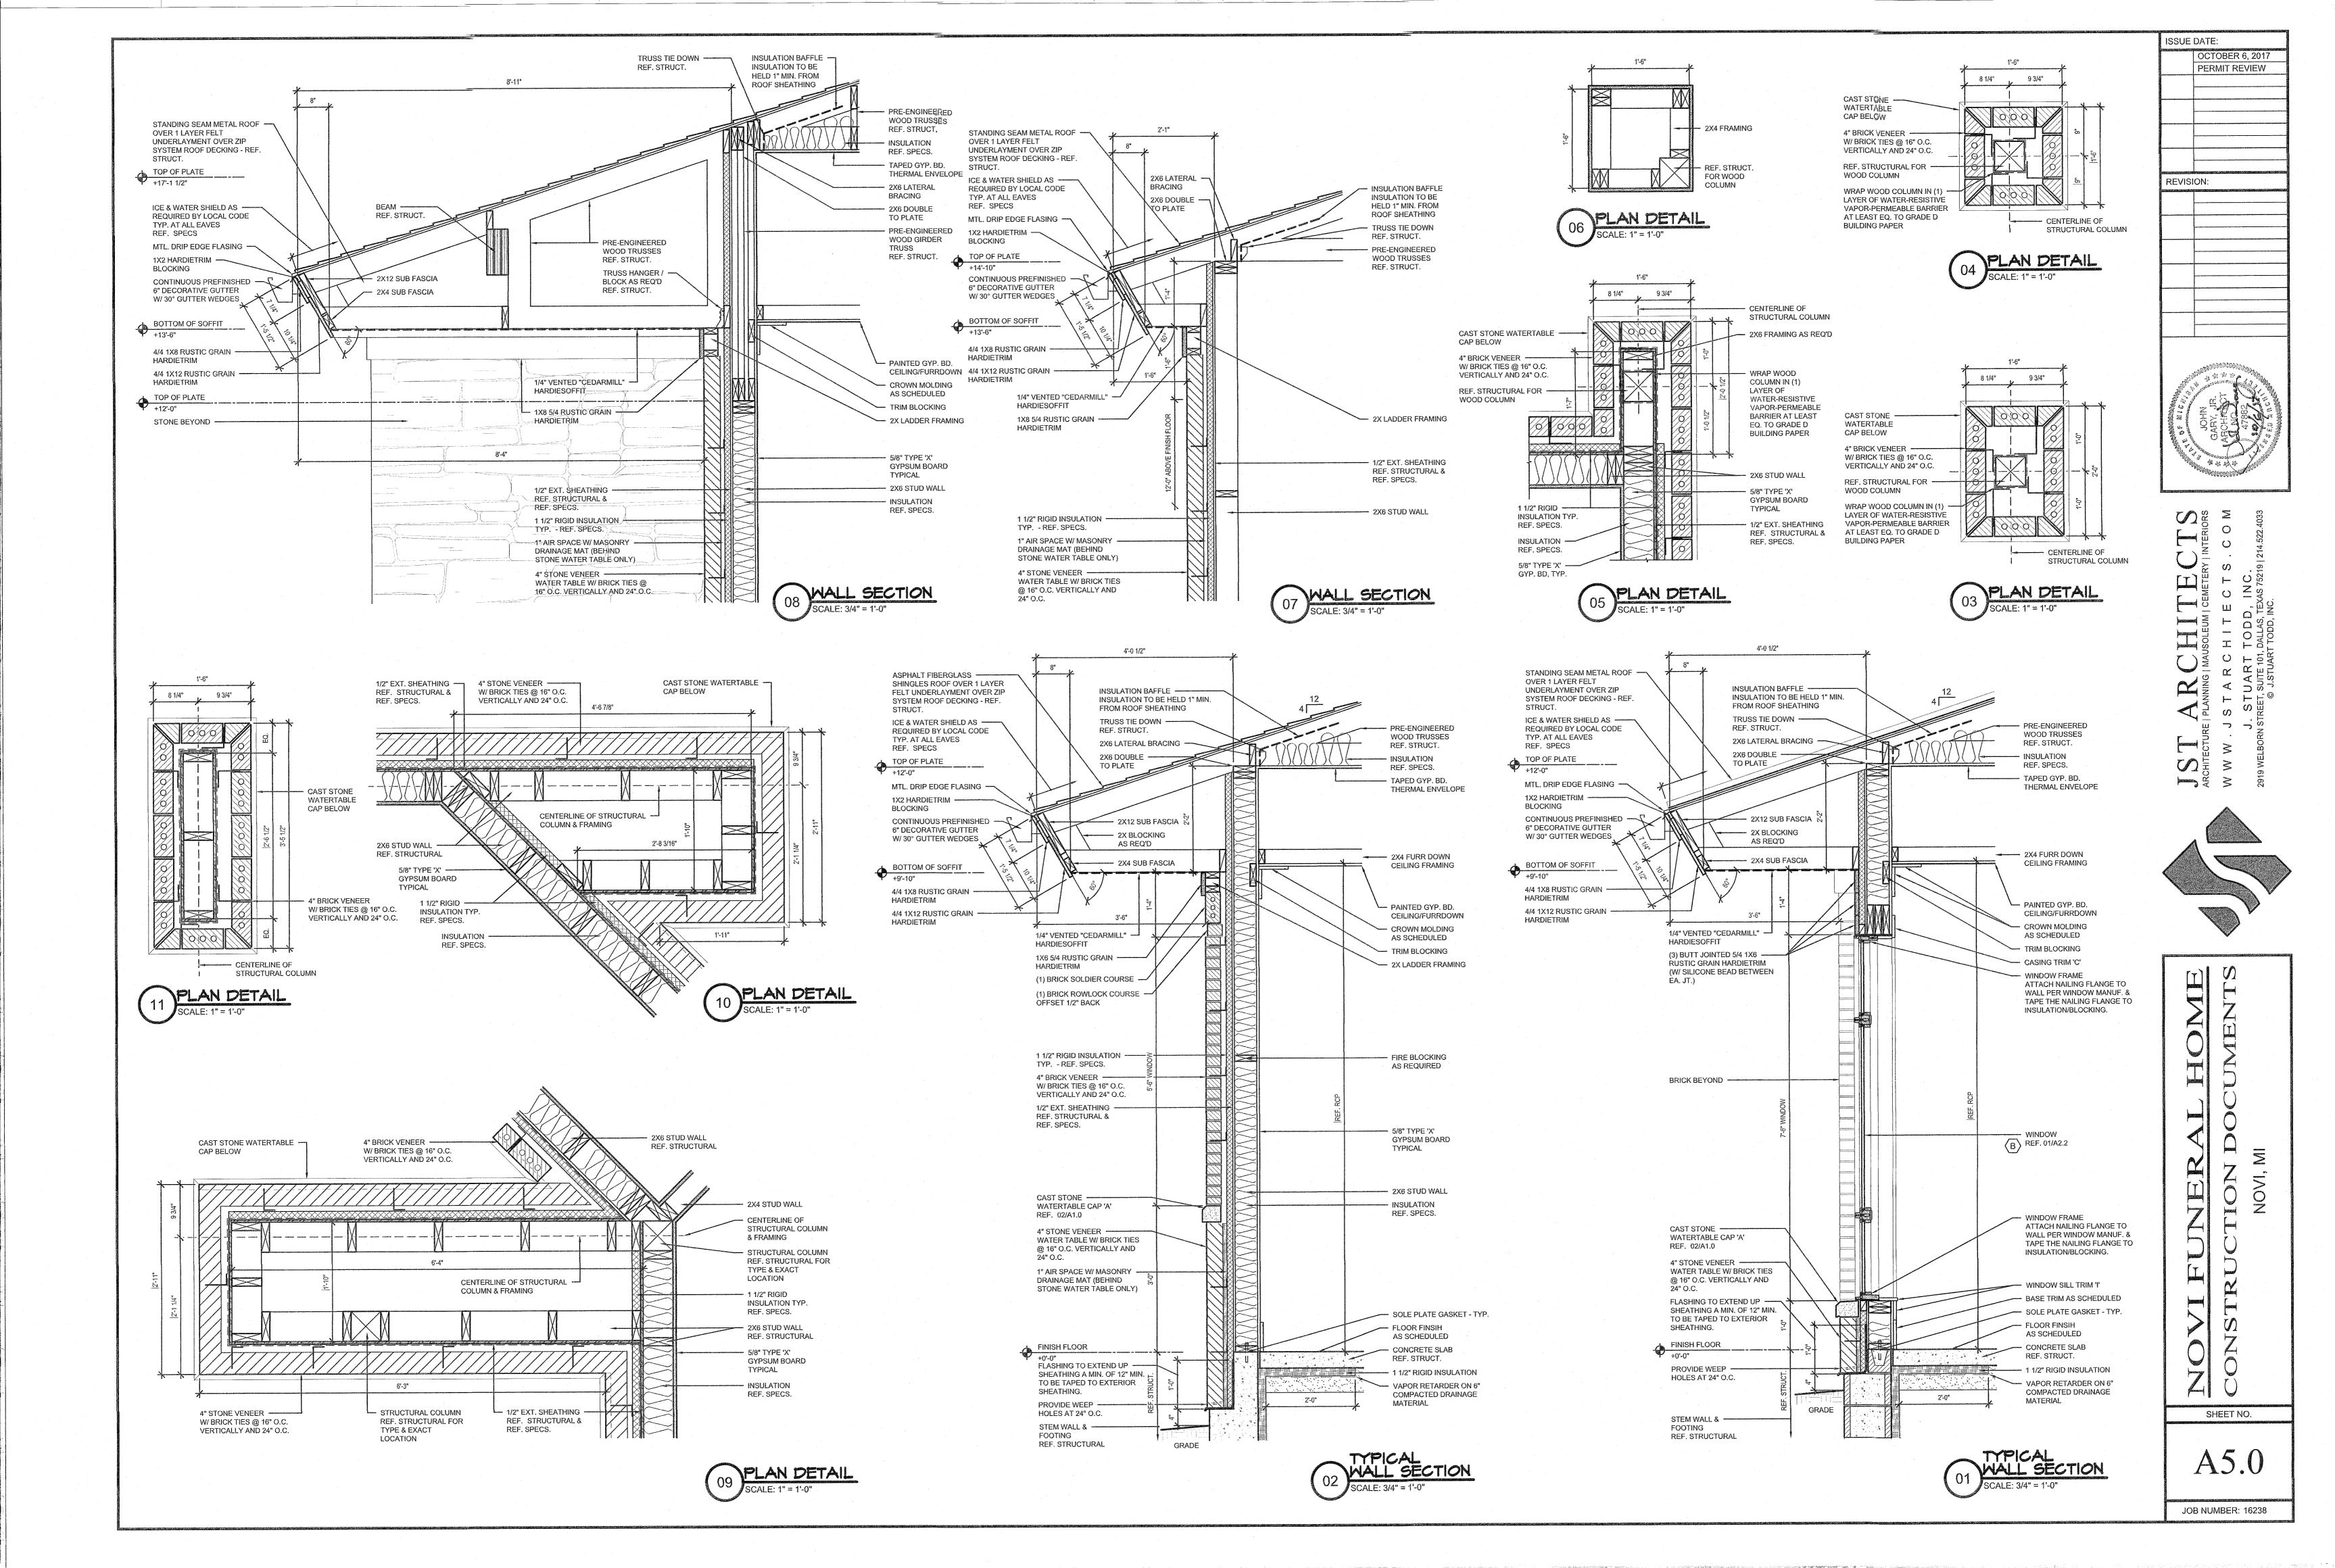


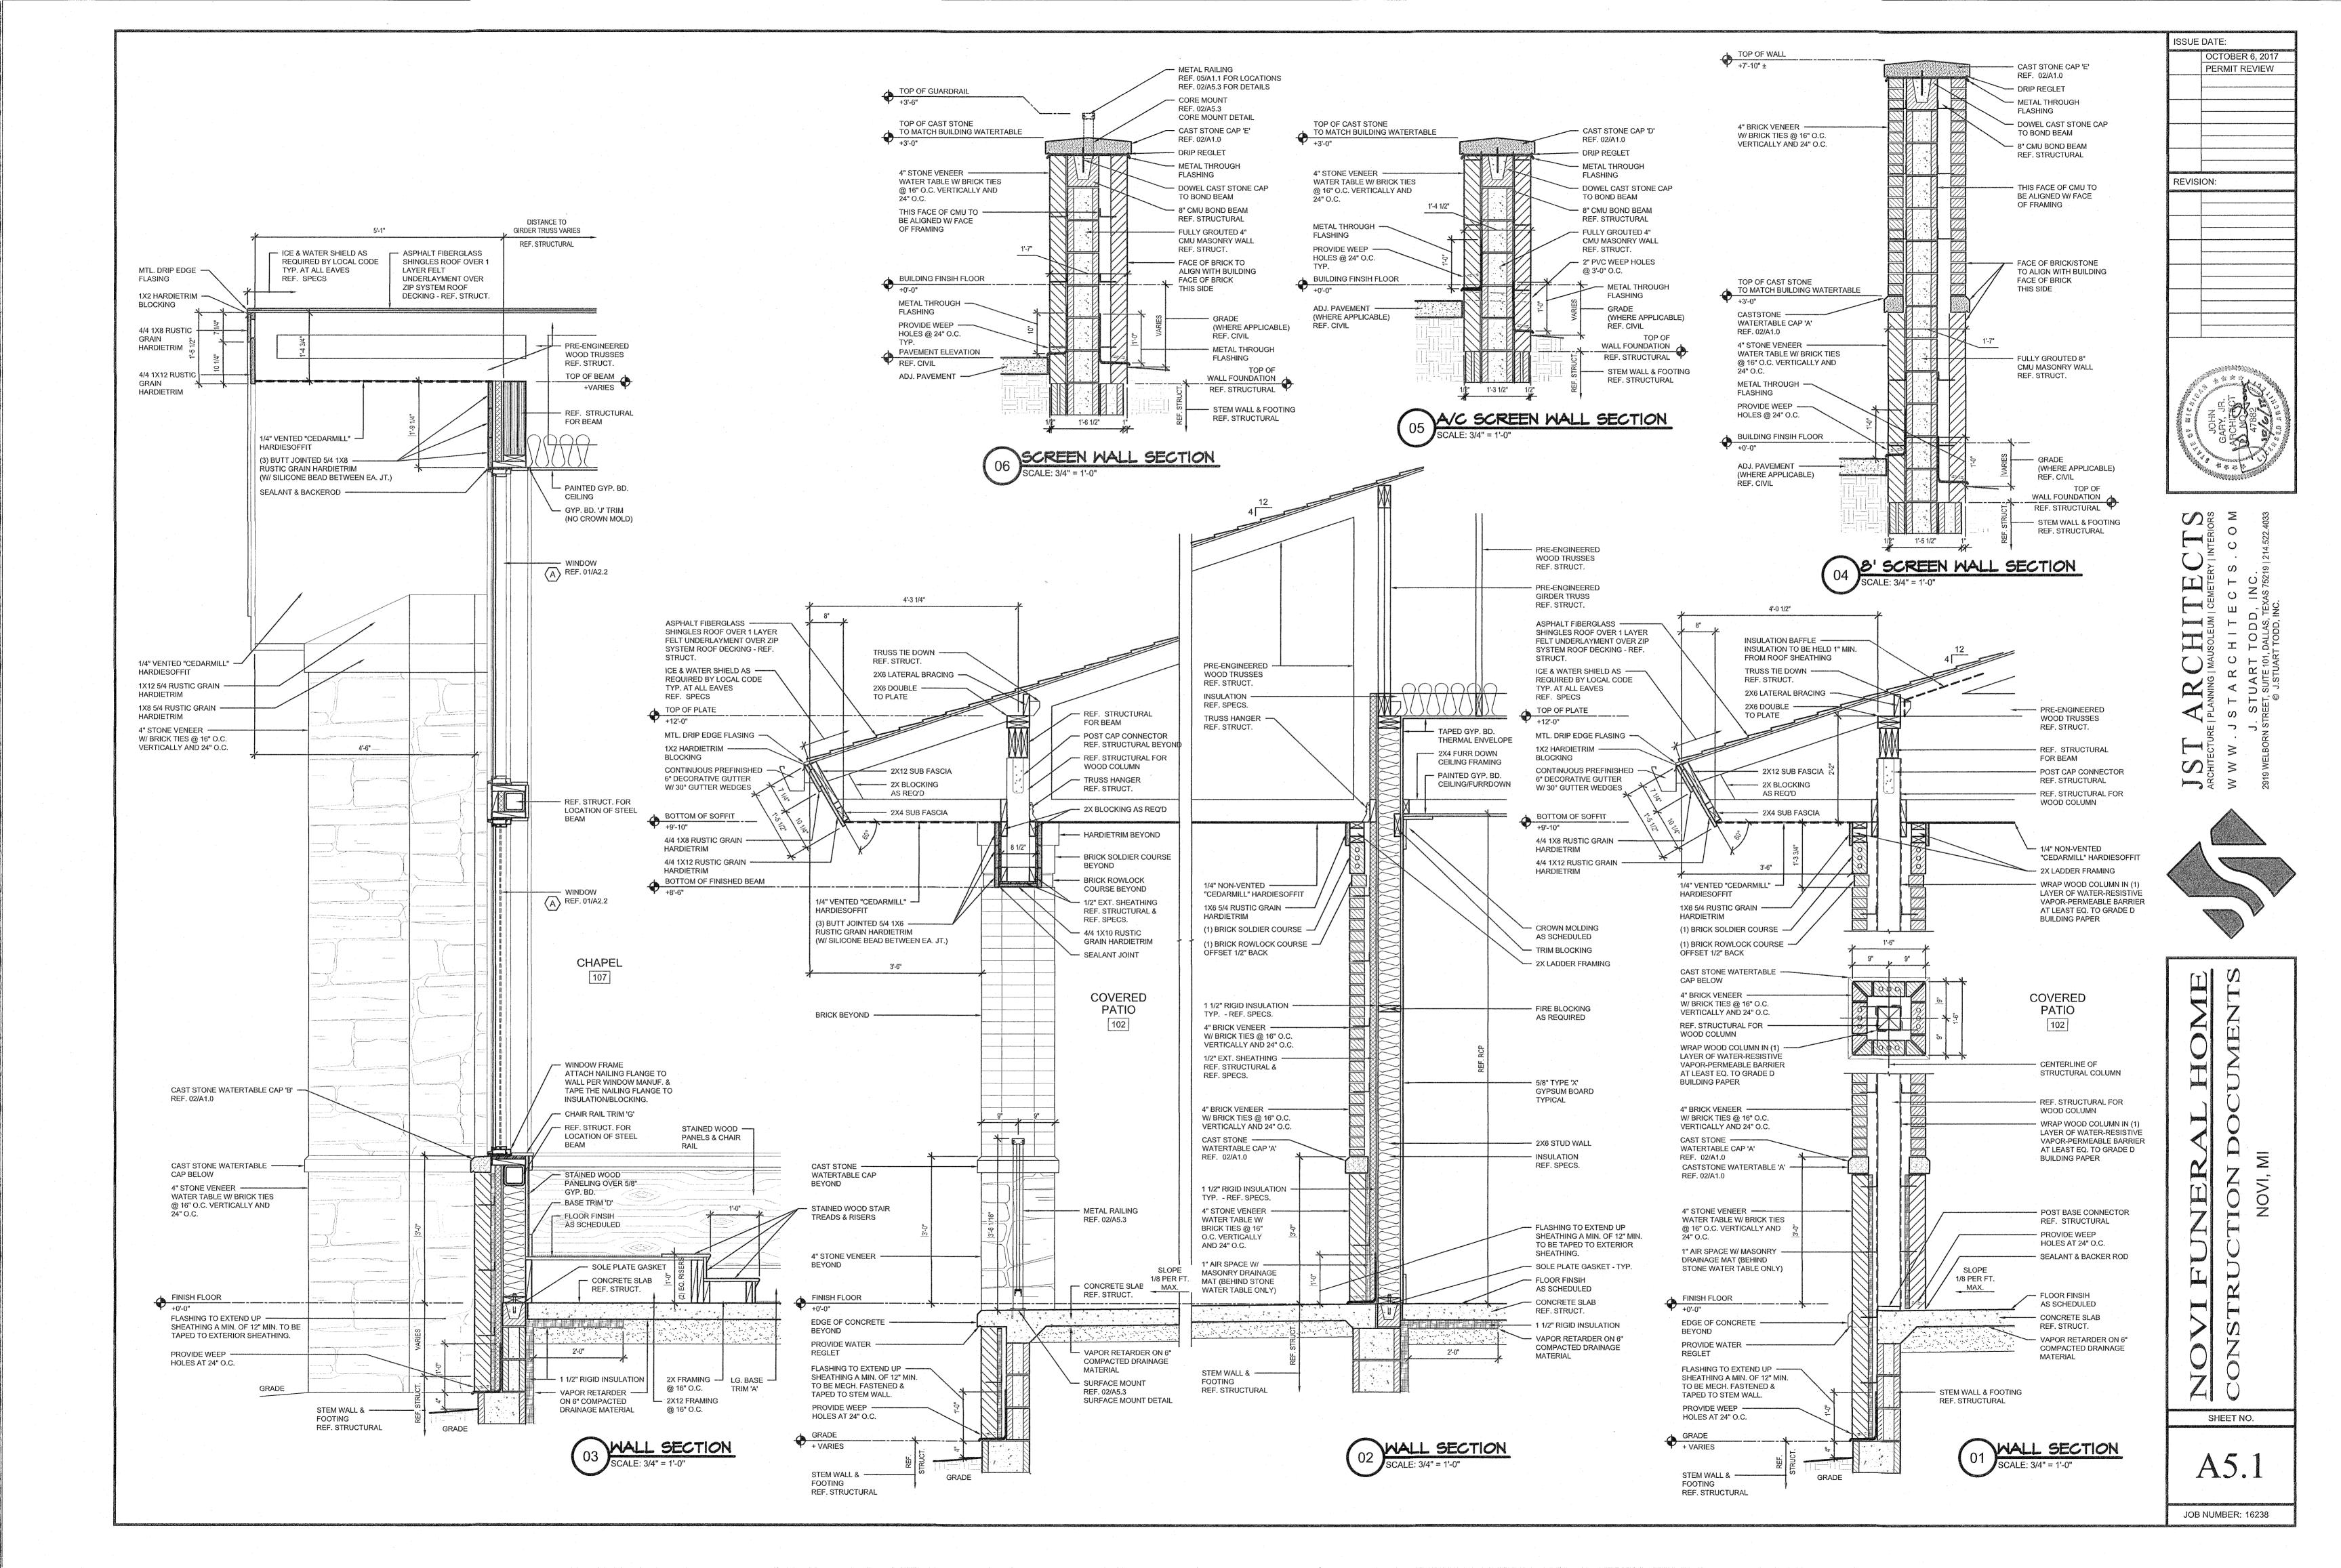


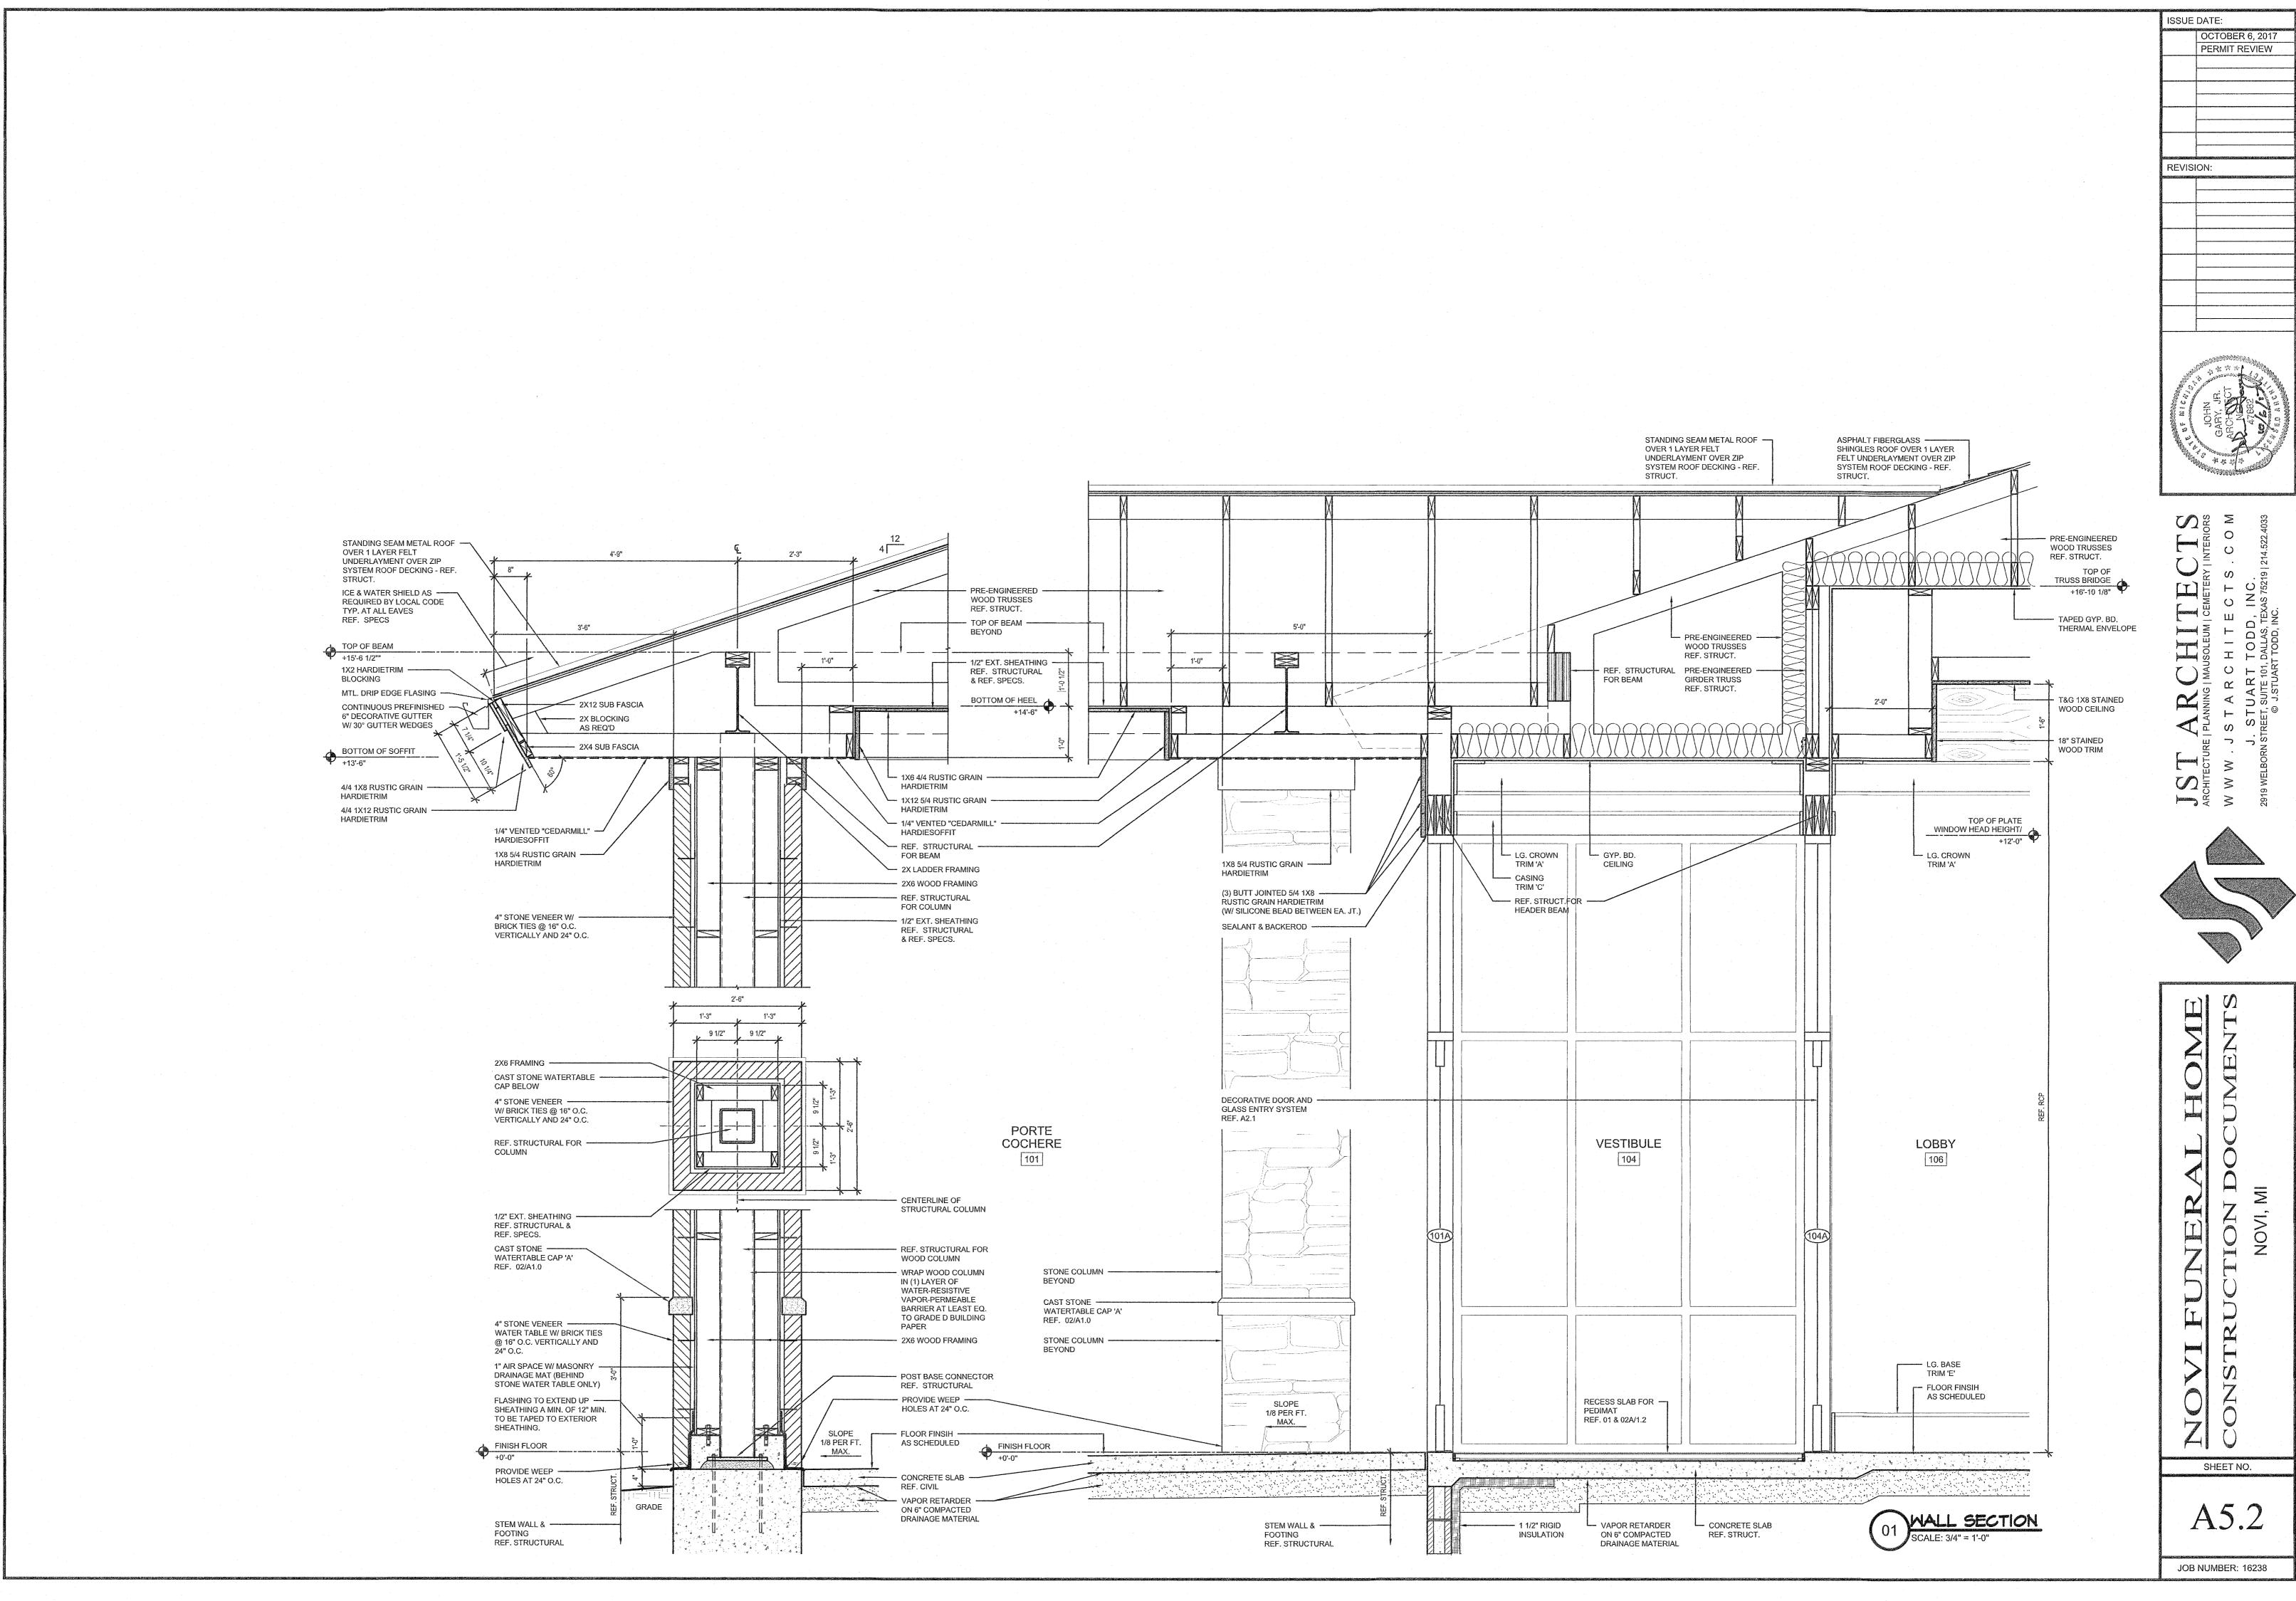

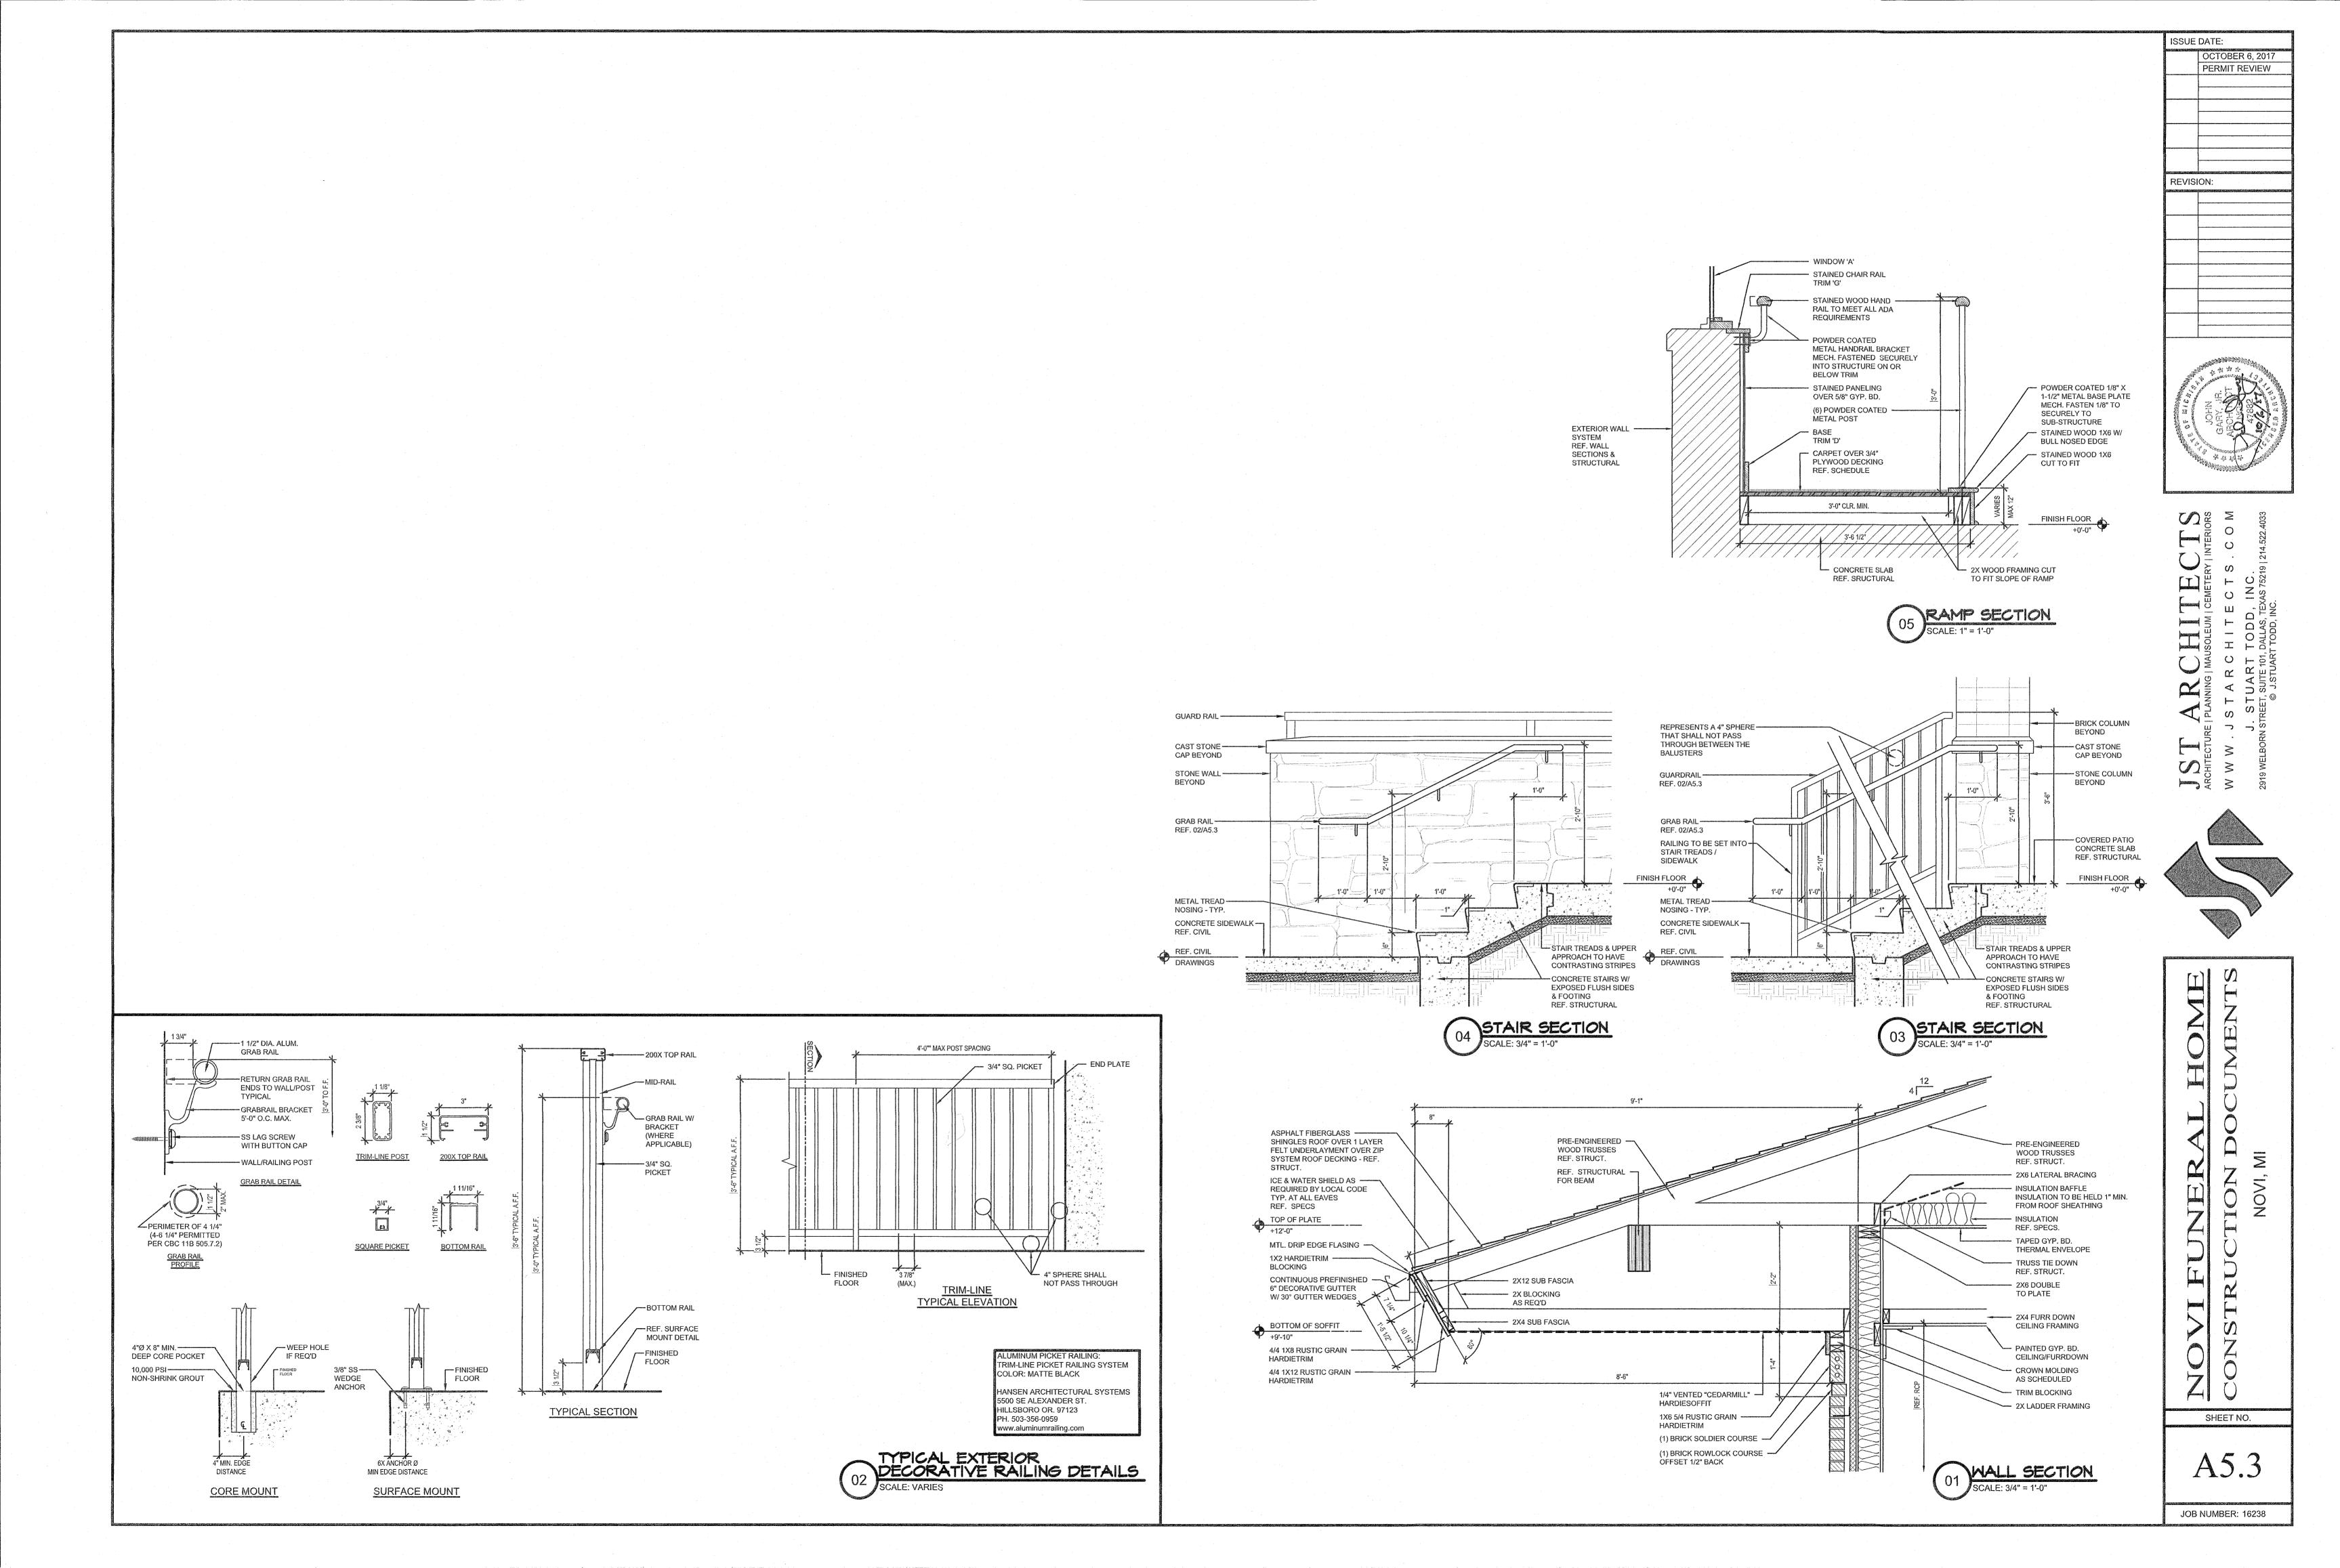


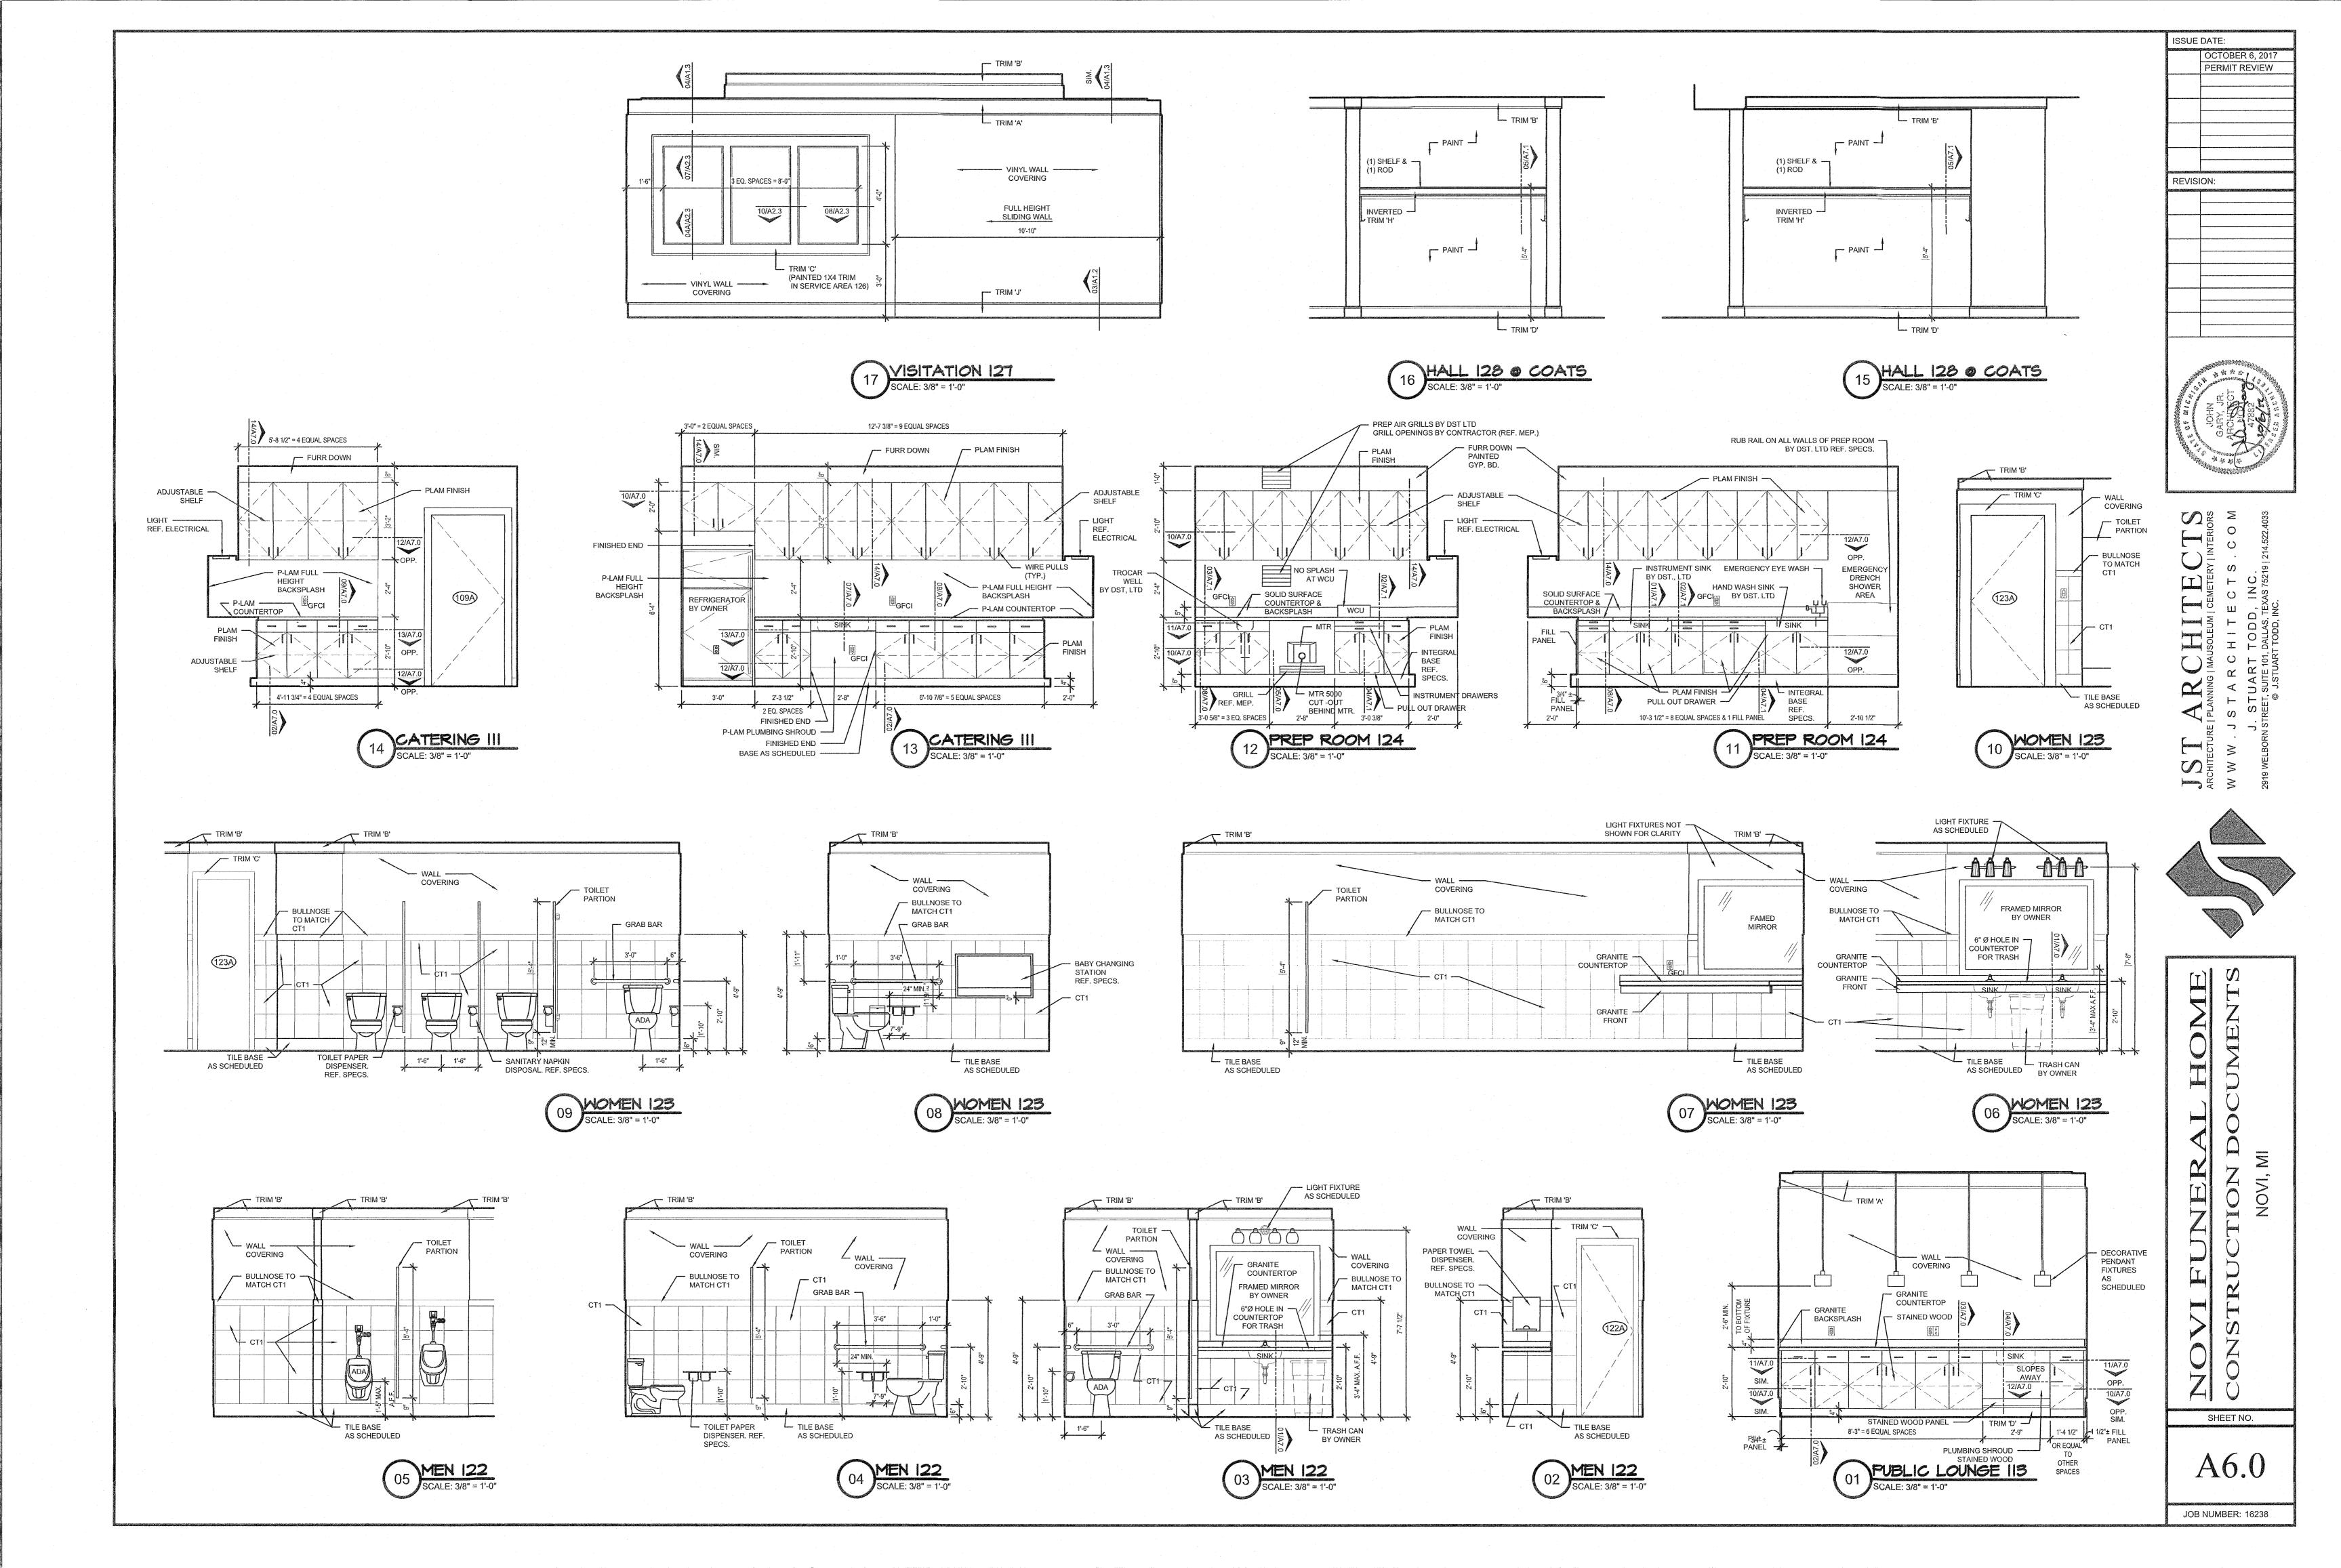

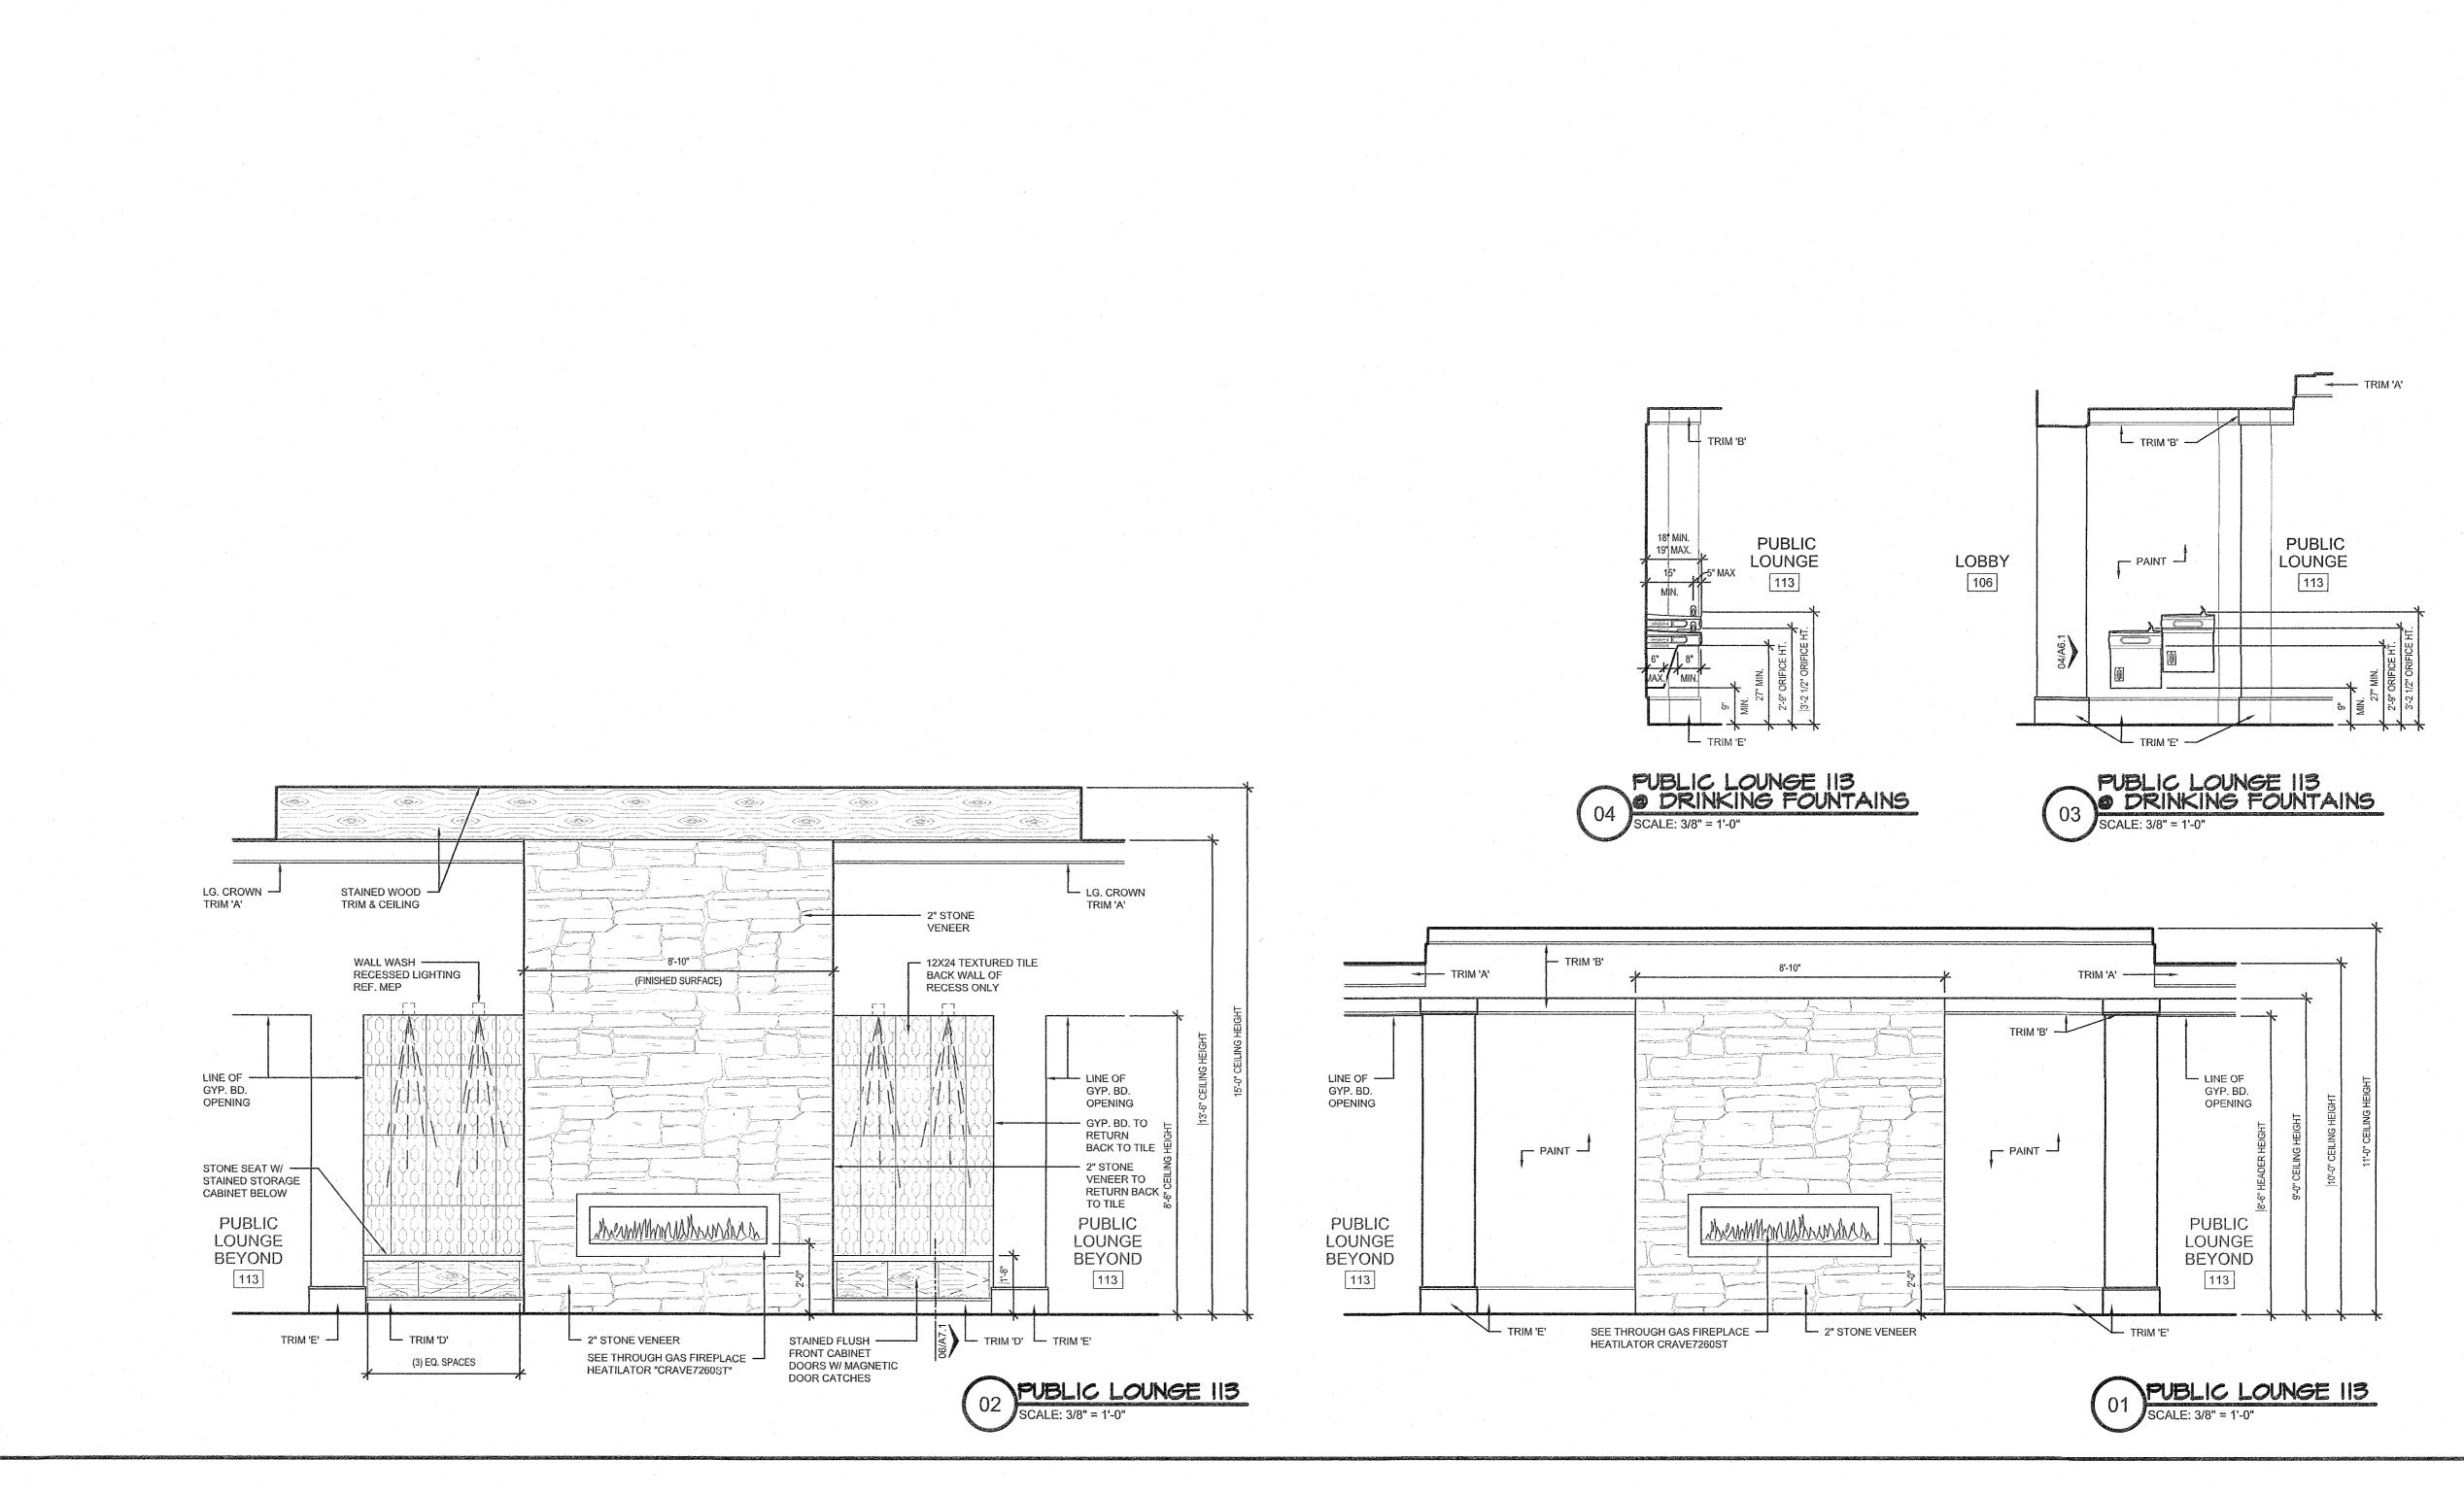

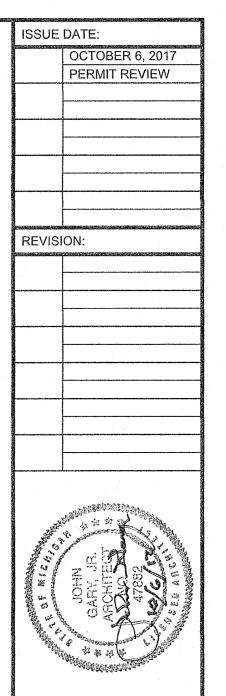



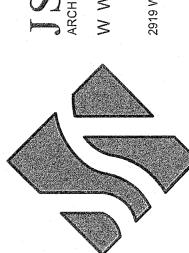

VI FUNTERAL HOME
STRUCTION DOCUMENTS
NOW, MI

SHEET NO.

A6.1

JOB NUMBER: 16238

Z

